




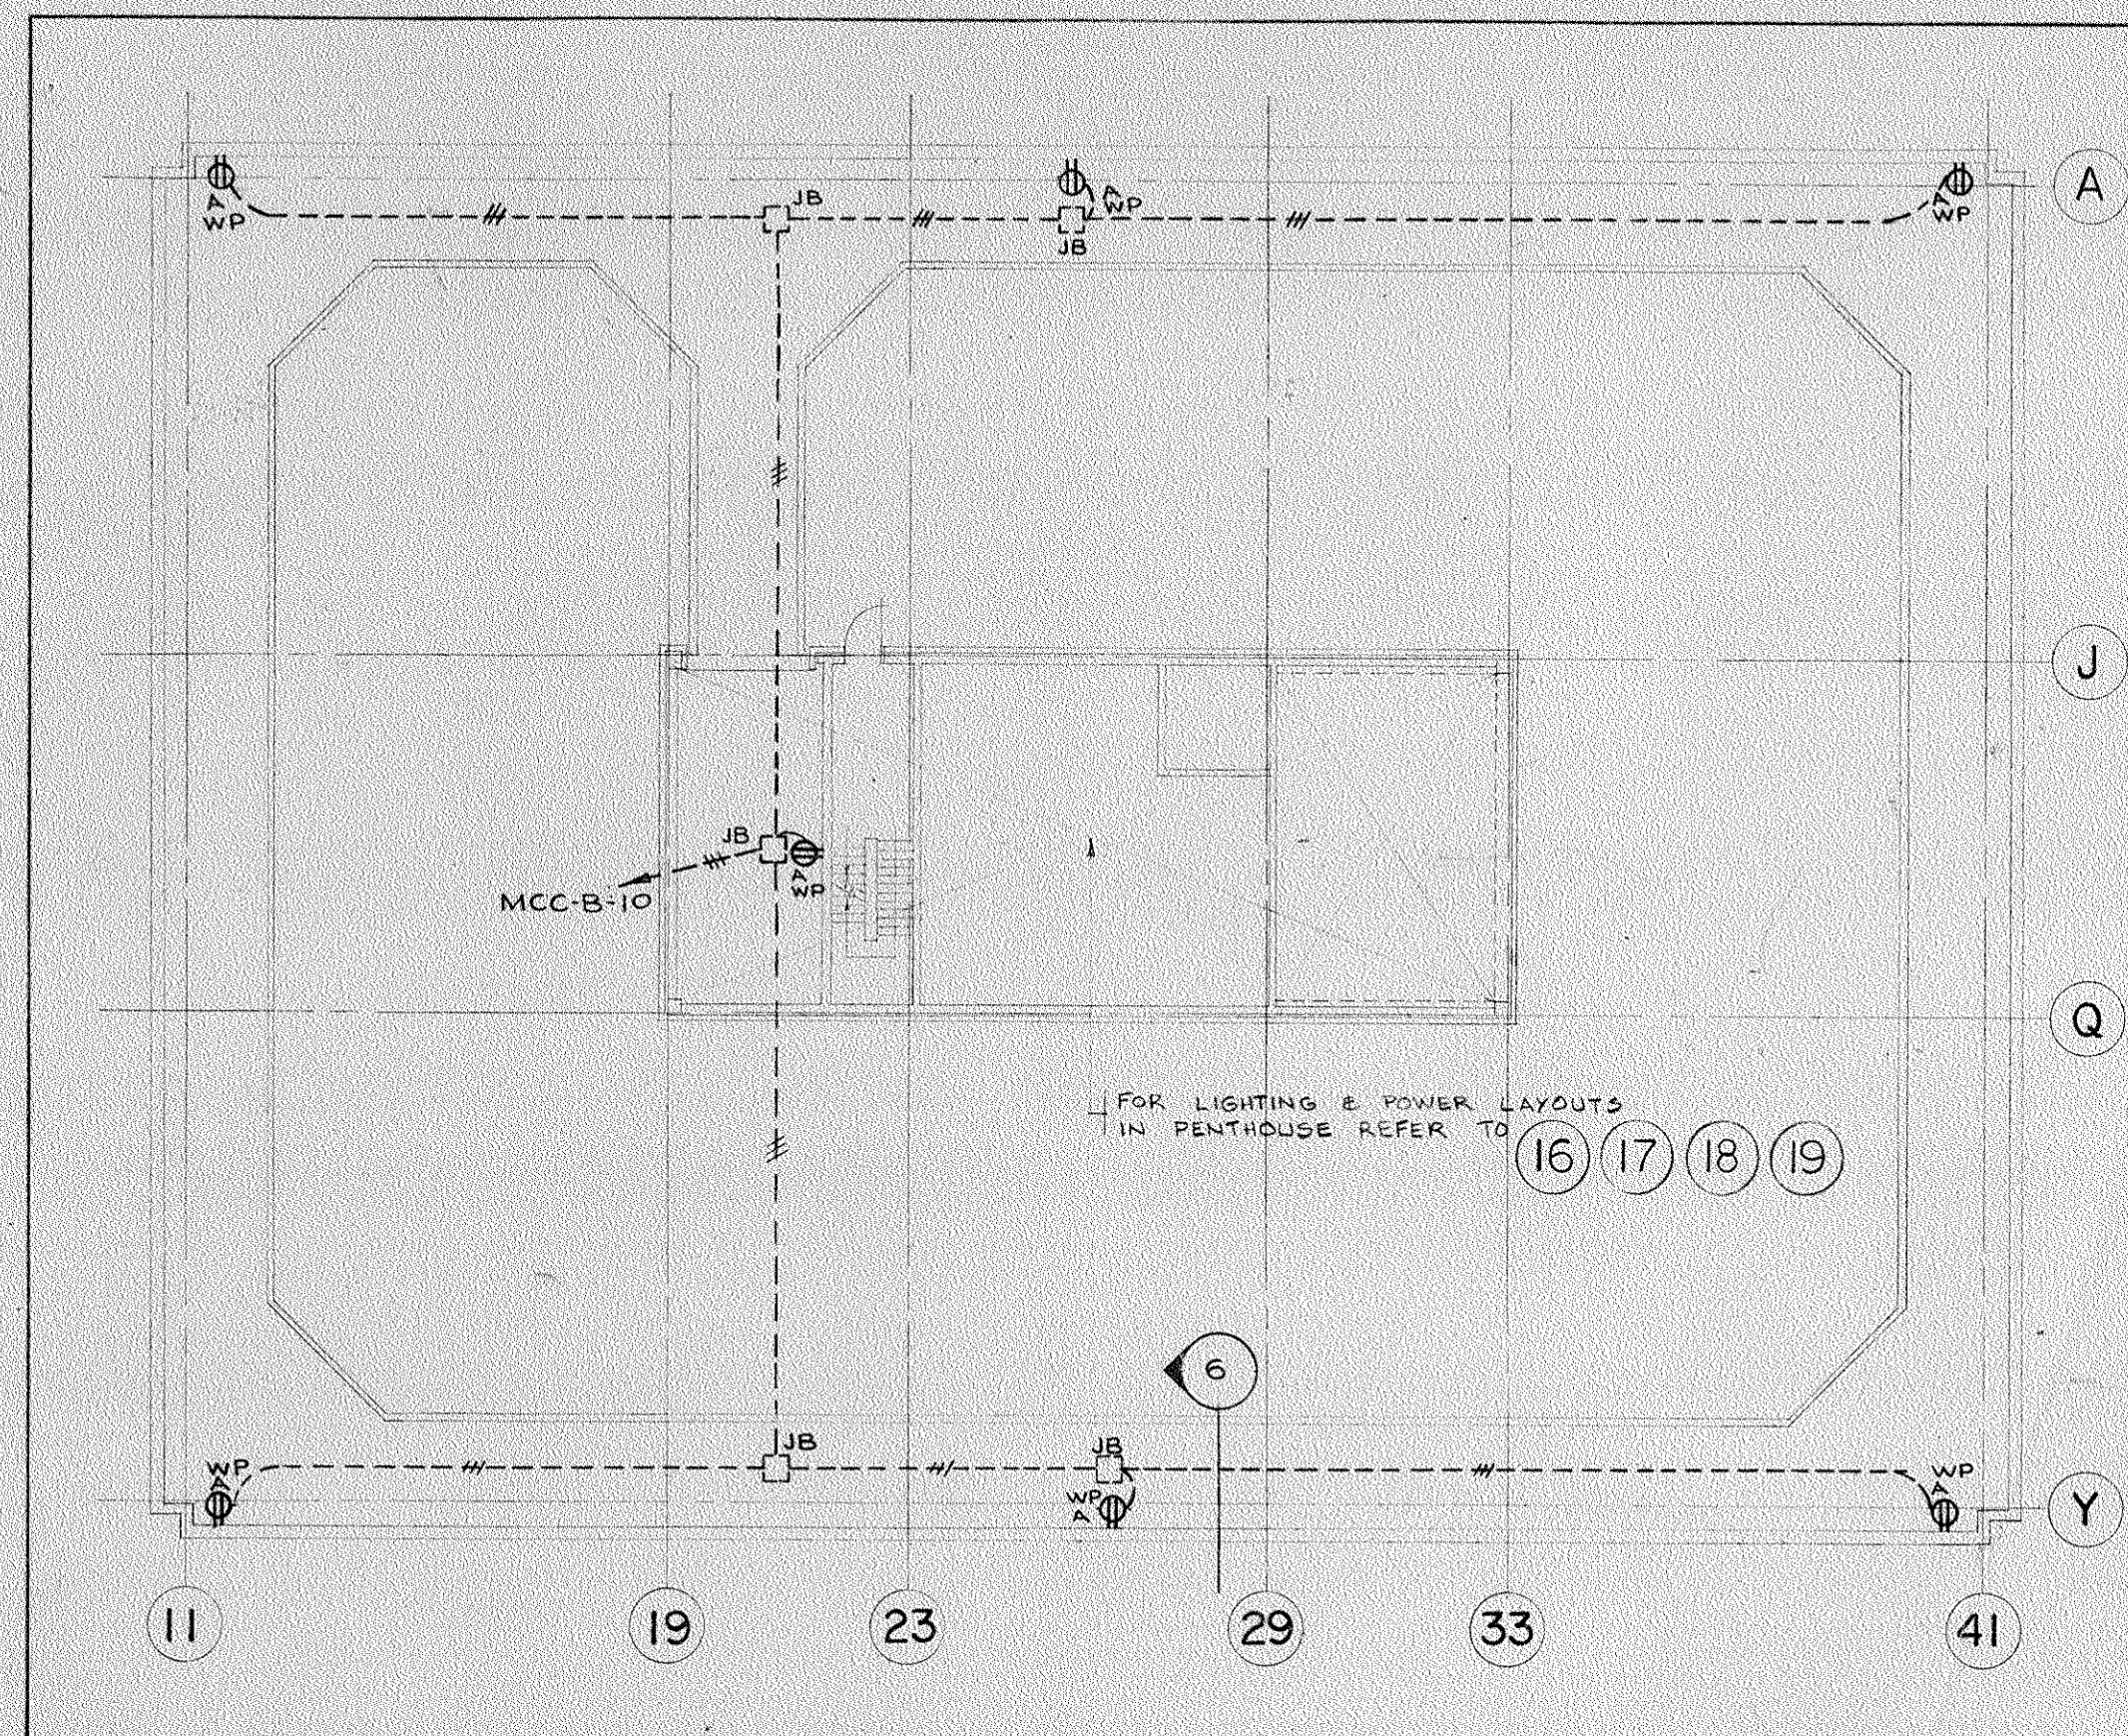


① WINDOW WASHING EQUIPMENT POWER LAYOUT ON ROOF
SCALE 1/16"=1'-0"

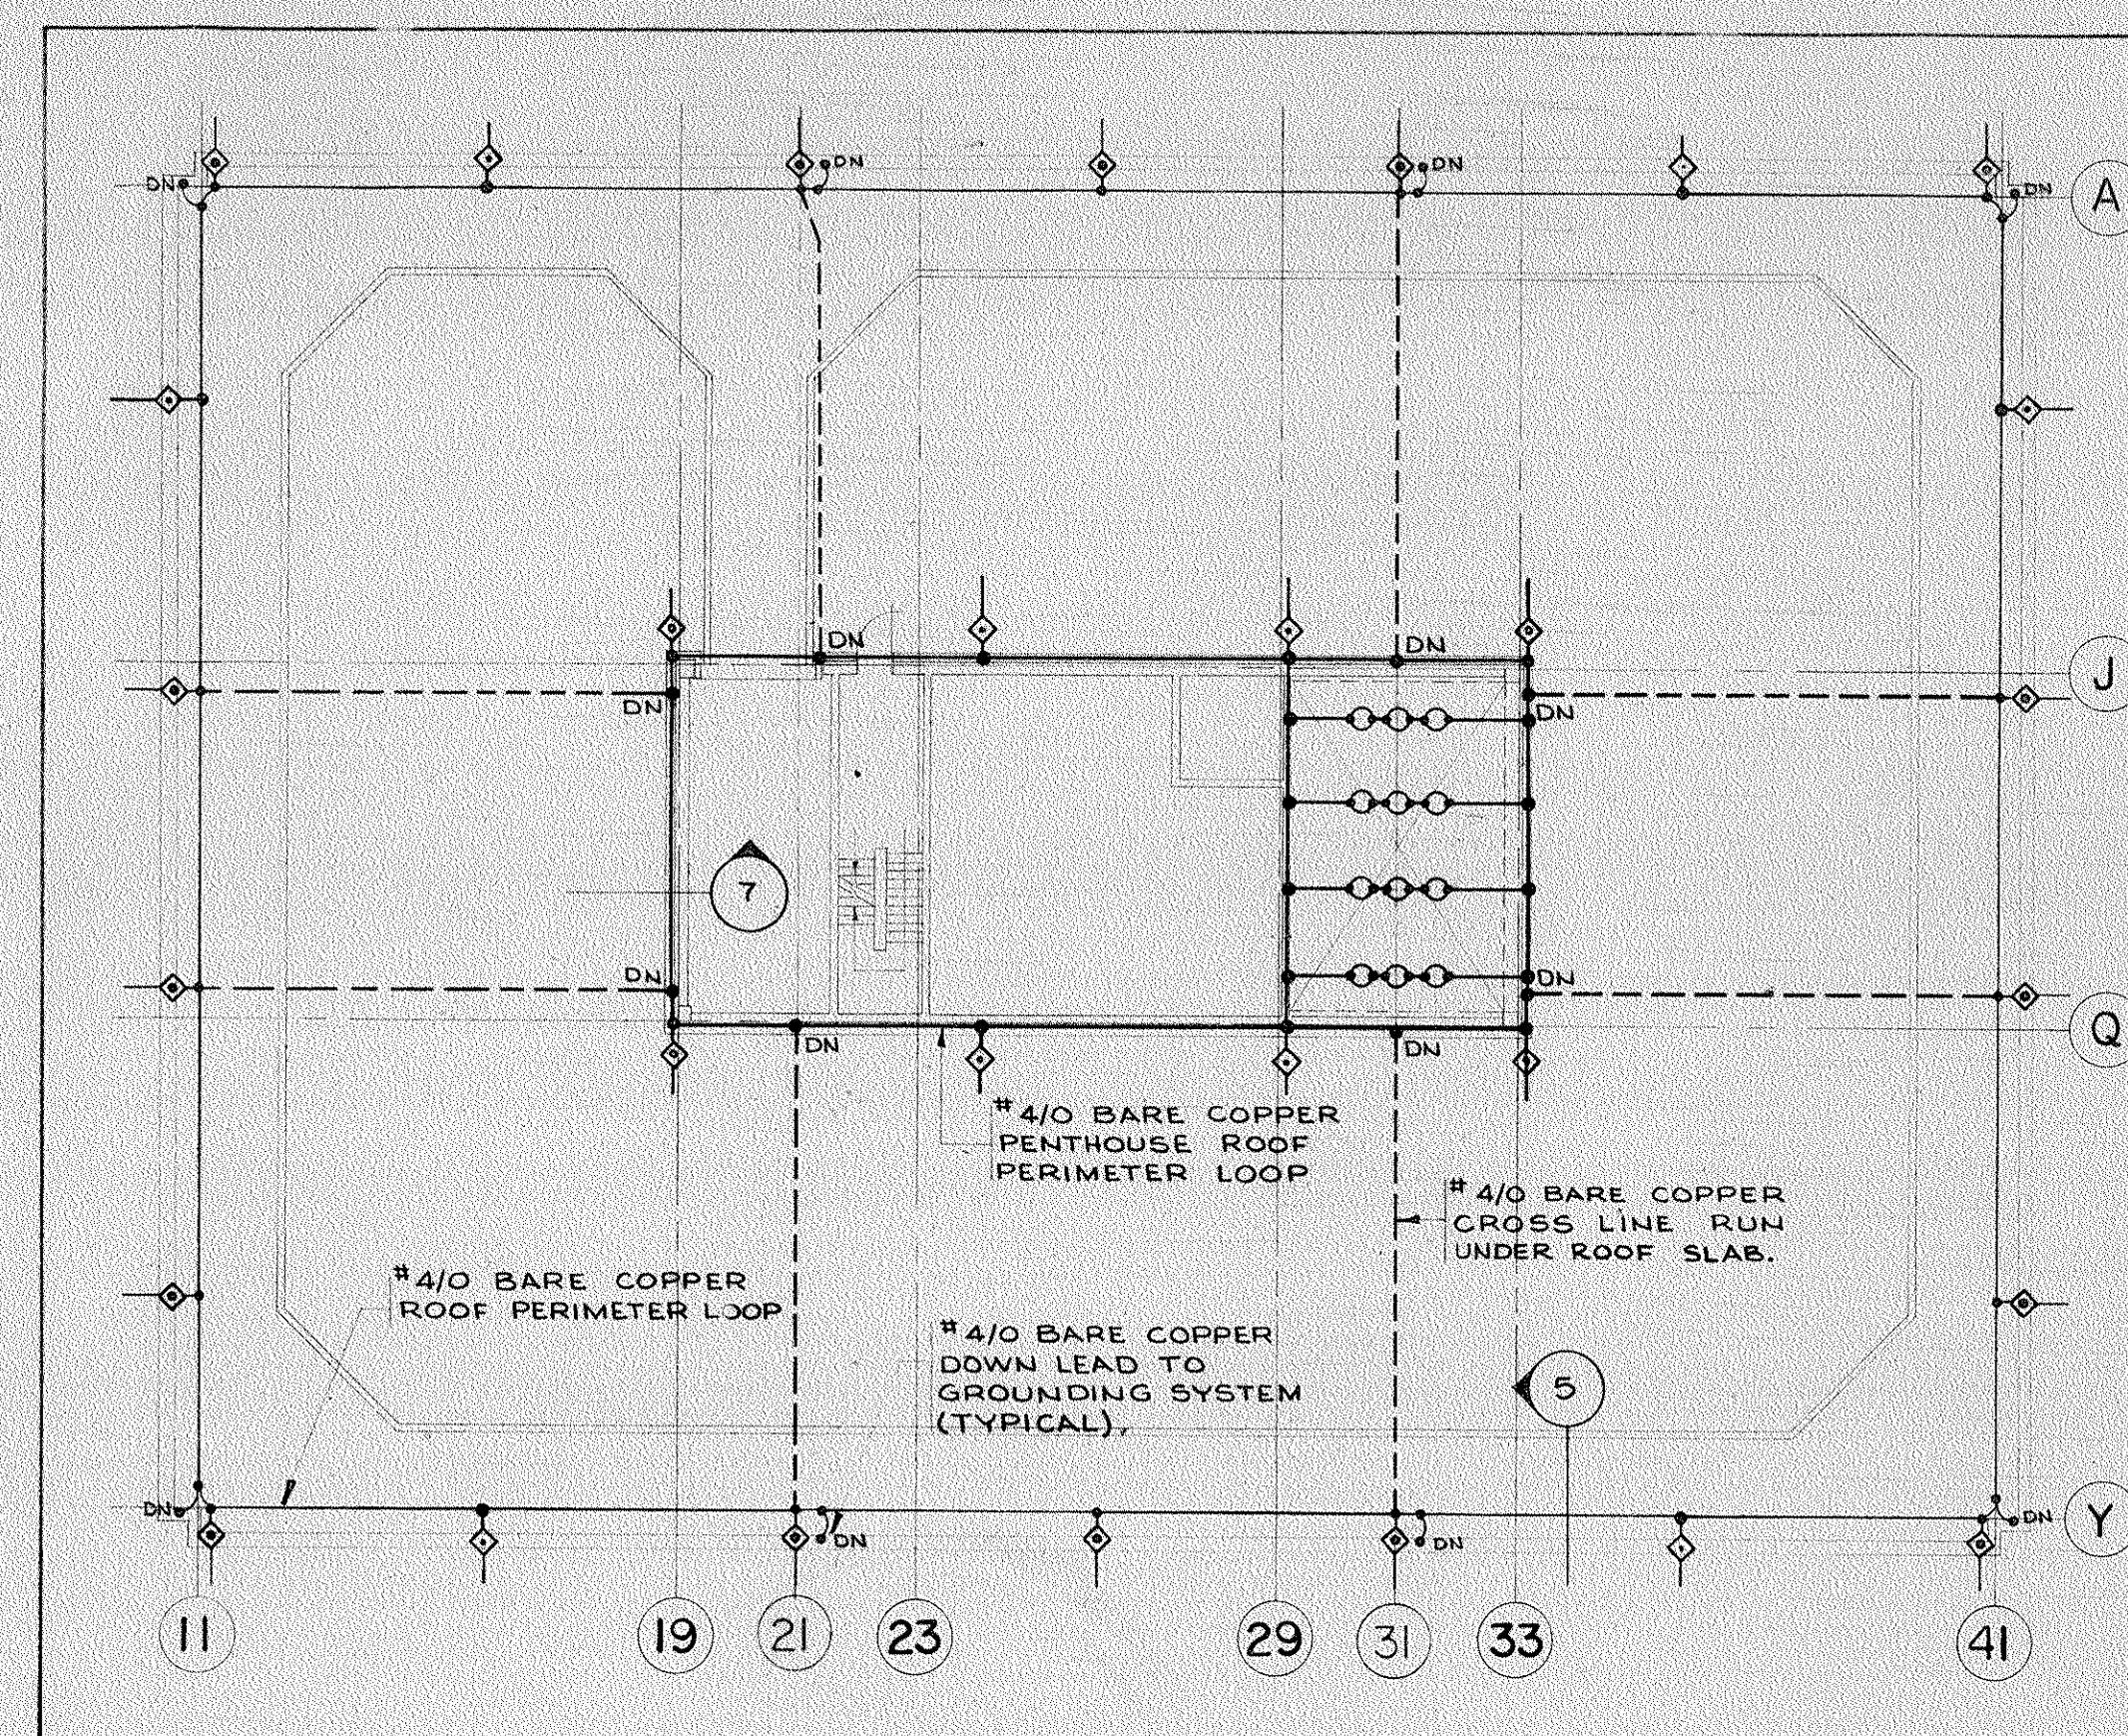


② LIGHTNING PROTECTION SYSTEM ON ROOF
SCALE 1/16" = 1'-0"

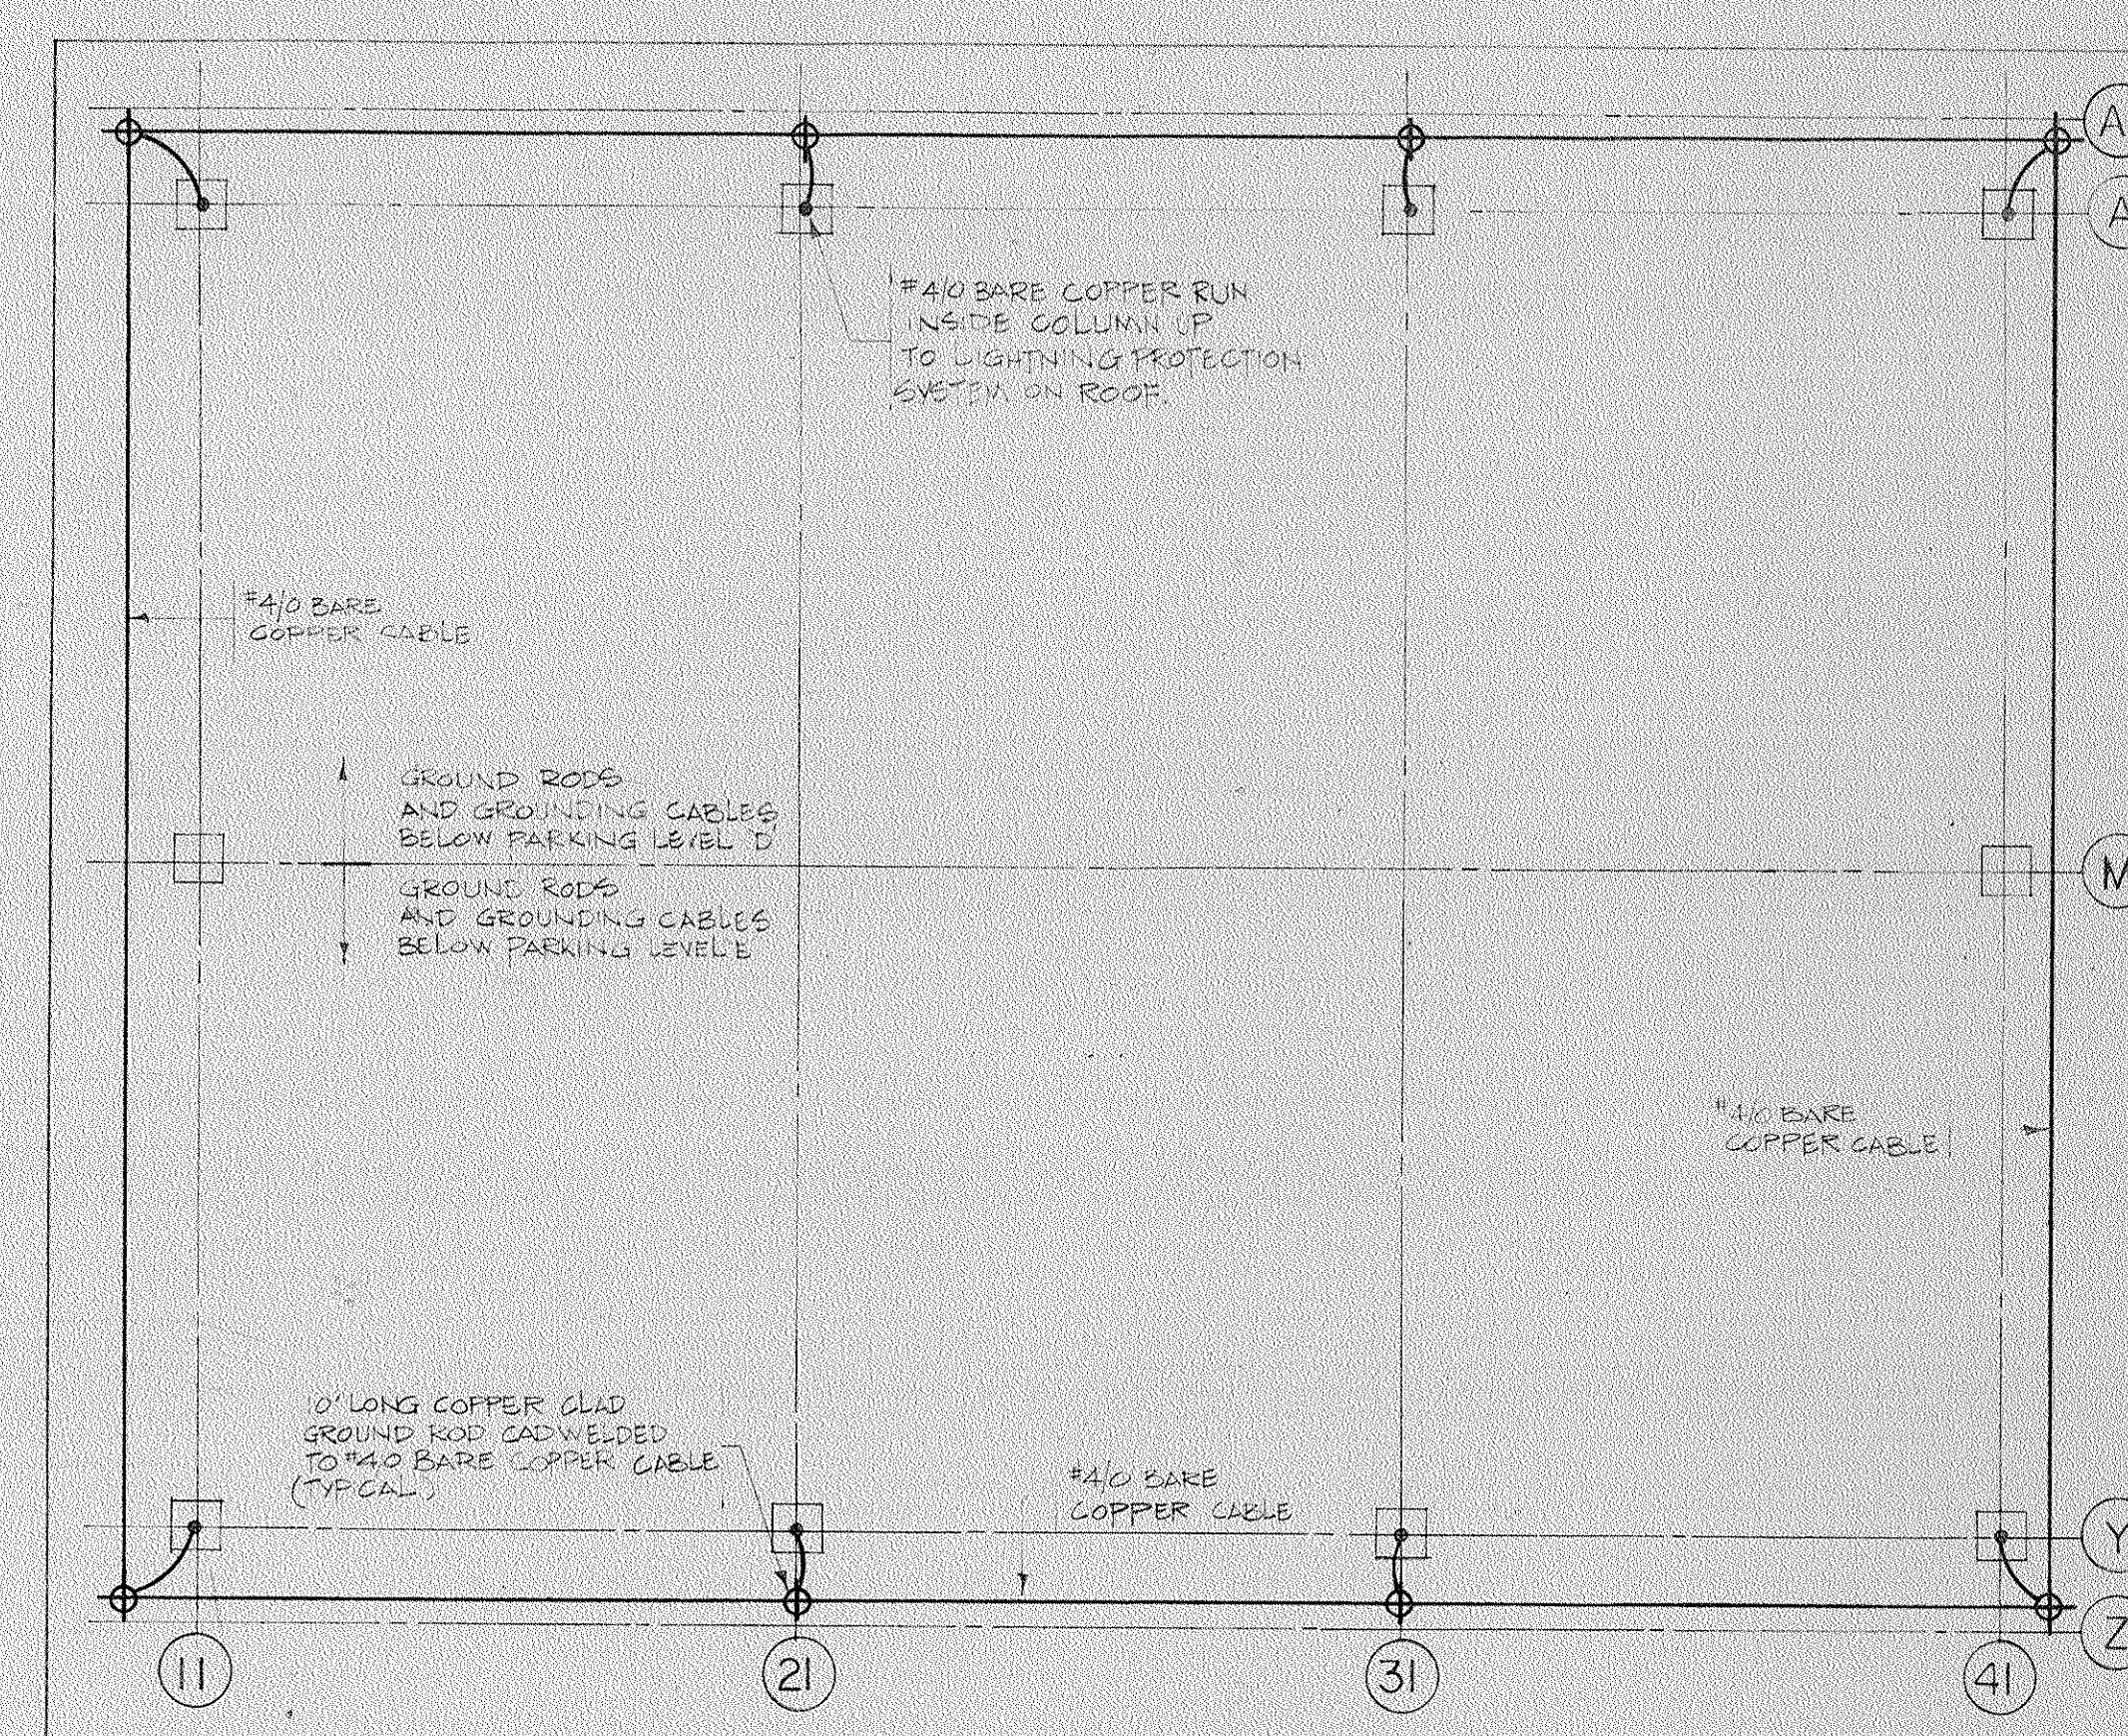


③ GROUNDING FOR LIGHTNING PROTECTION SYSTEM
SCALE 1/16"=1'-0"

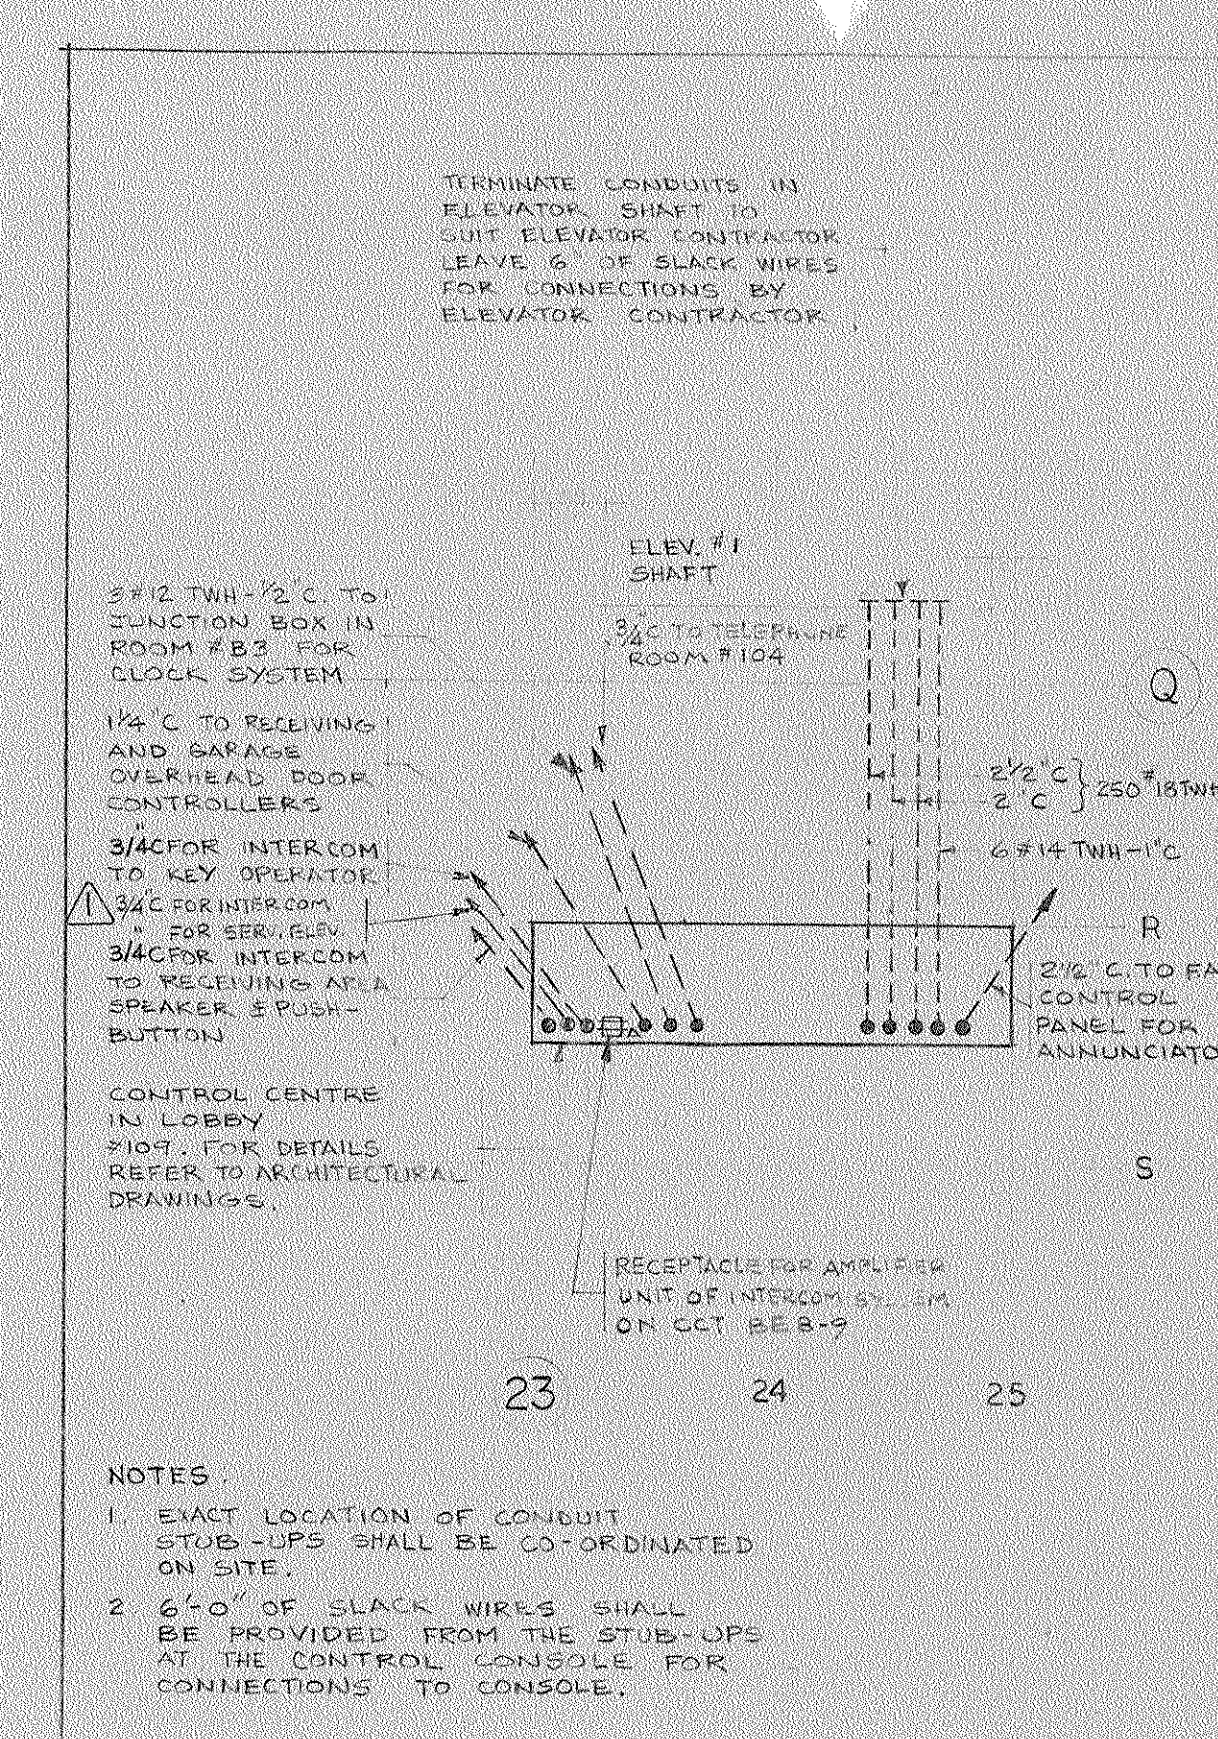


④ PLAN SHOWING CONDUITS TO
CONTROL CENTRE SCALE: 1/4"=1'-0"

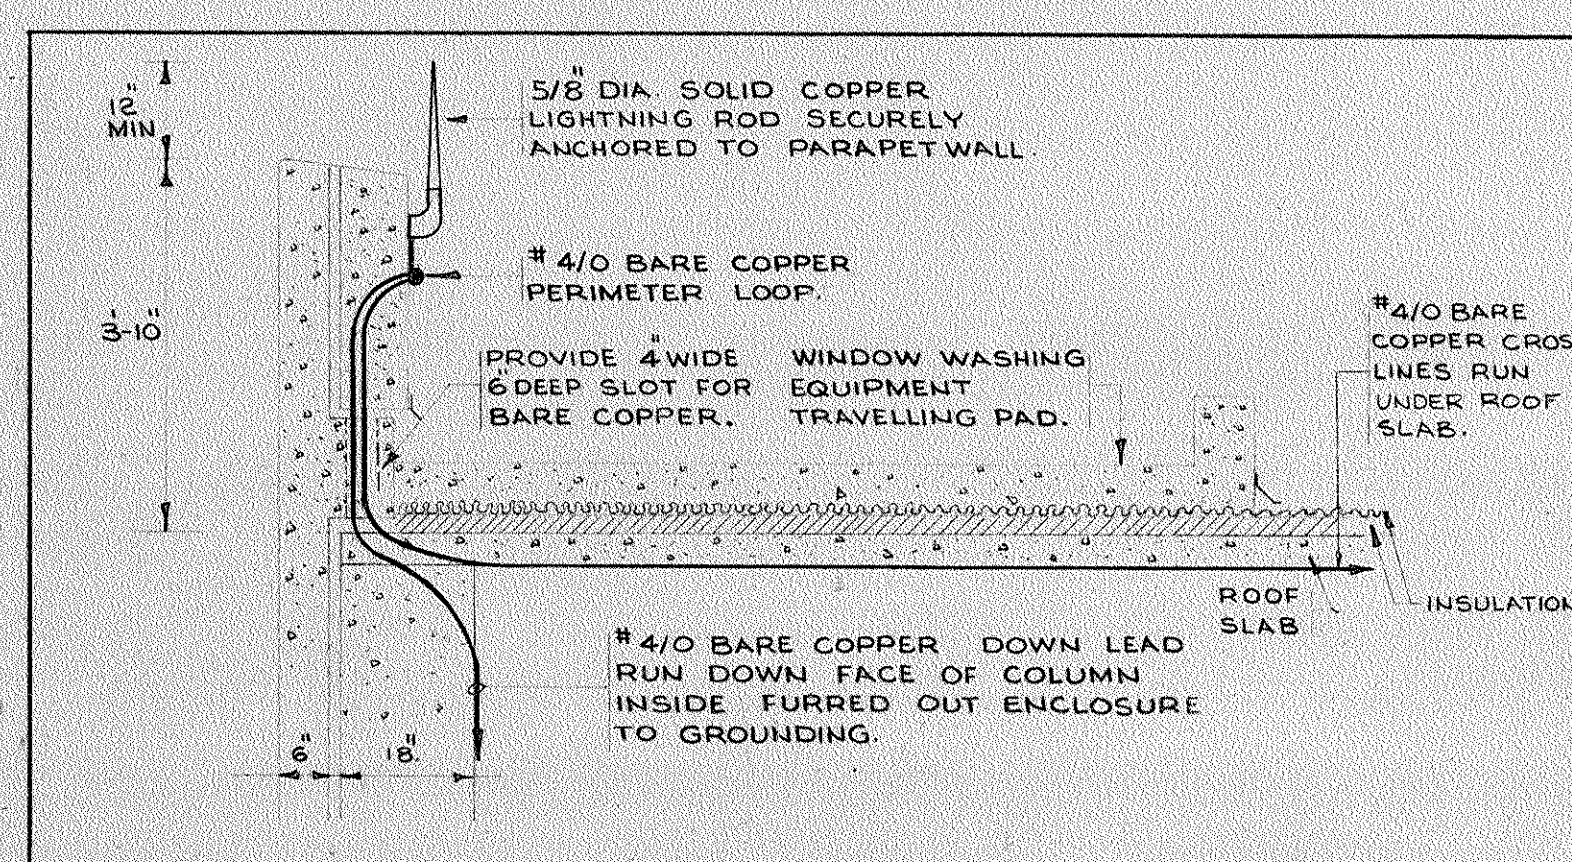


5 MOUNTING OF LIGHTNING ROD ON ROOF. SCALE
SCALE: 1/2" = 1'-0"

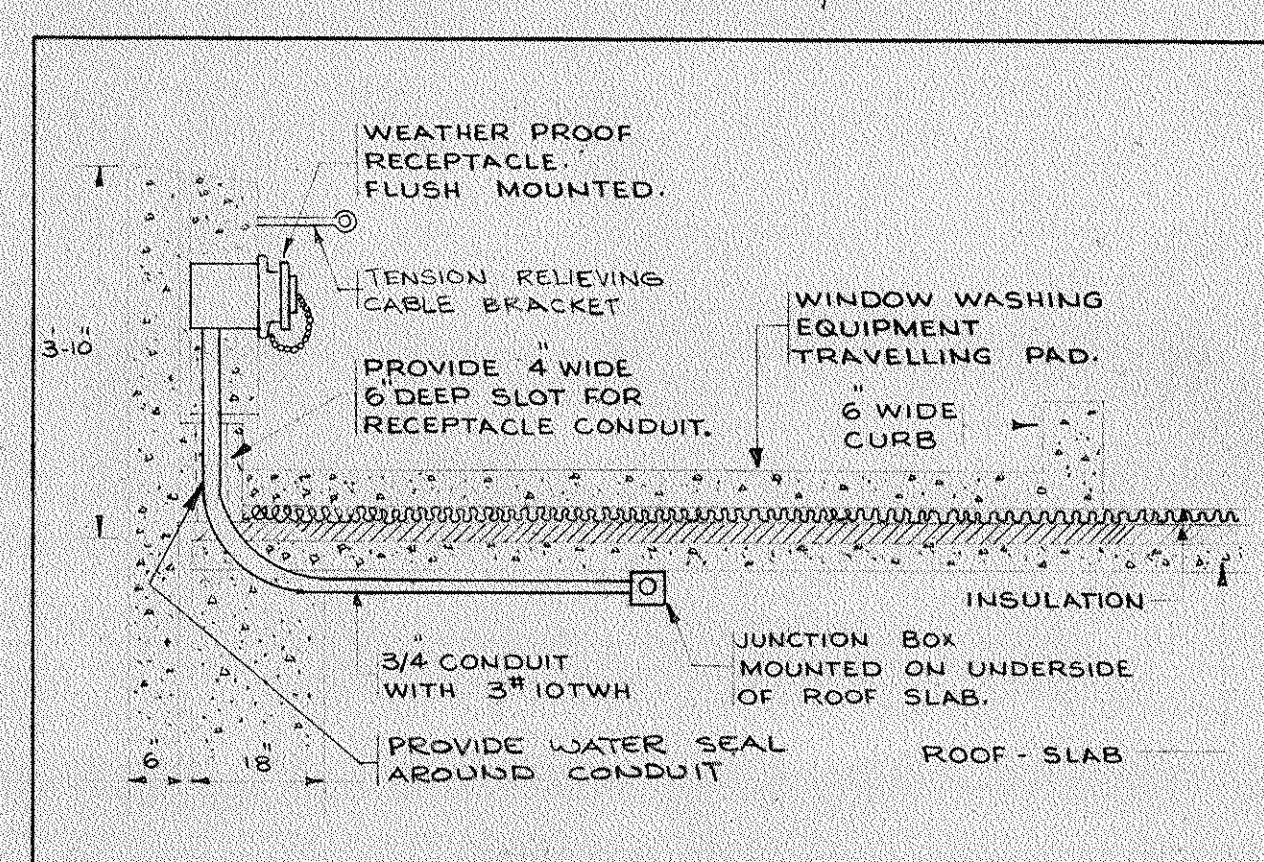


⑥ MOUNTING OF POWER OUTLET FOR WINDOW WASHING.
SCALE: 1/2"=1'-0"

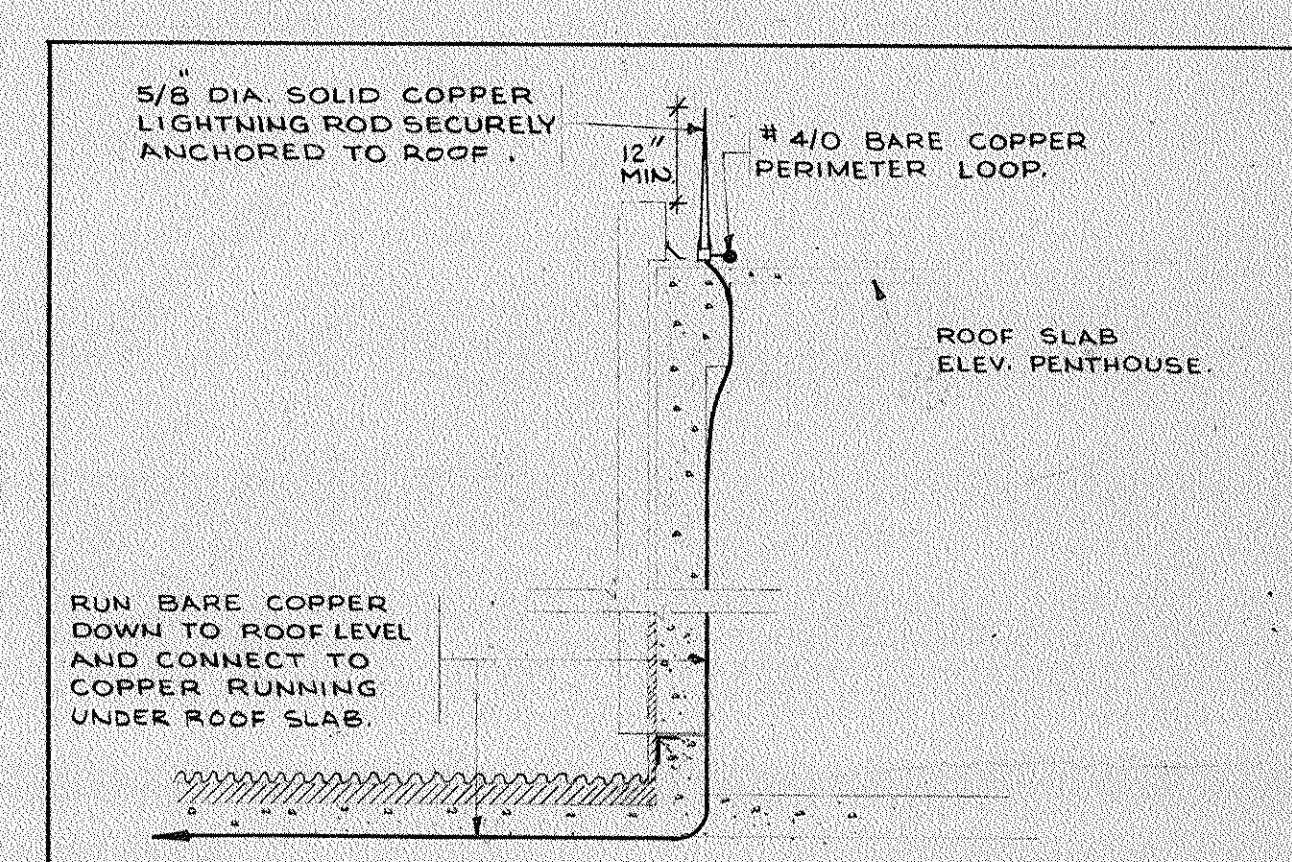


⑦ MOUNTING OF LIGHTNING ROD ON
PENTHOUSE ROOF. SCALE: $1/2" = 1'-0"$

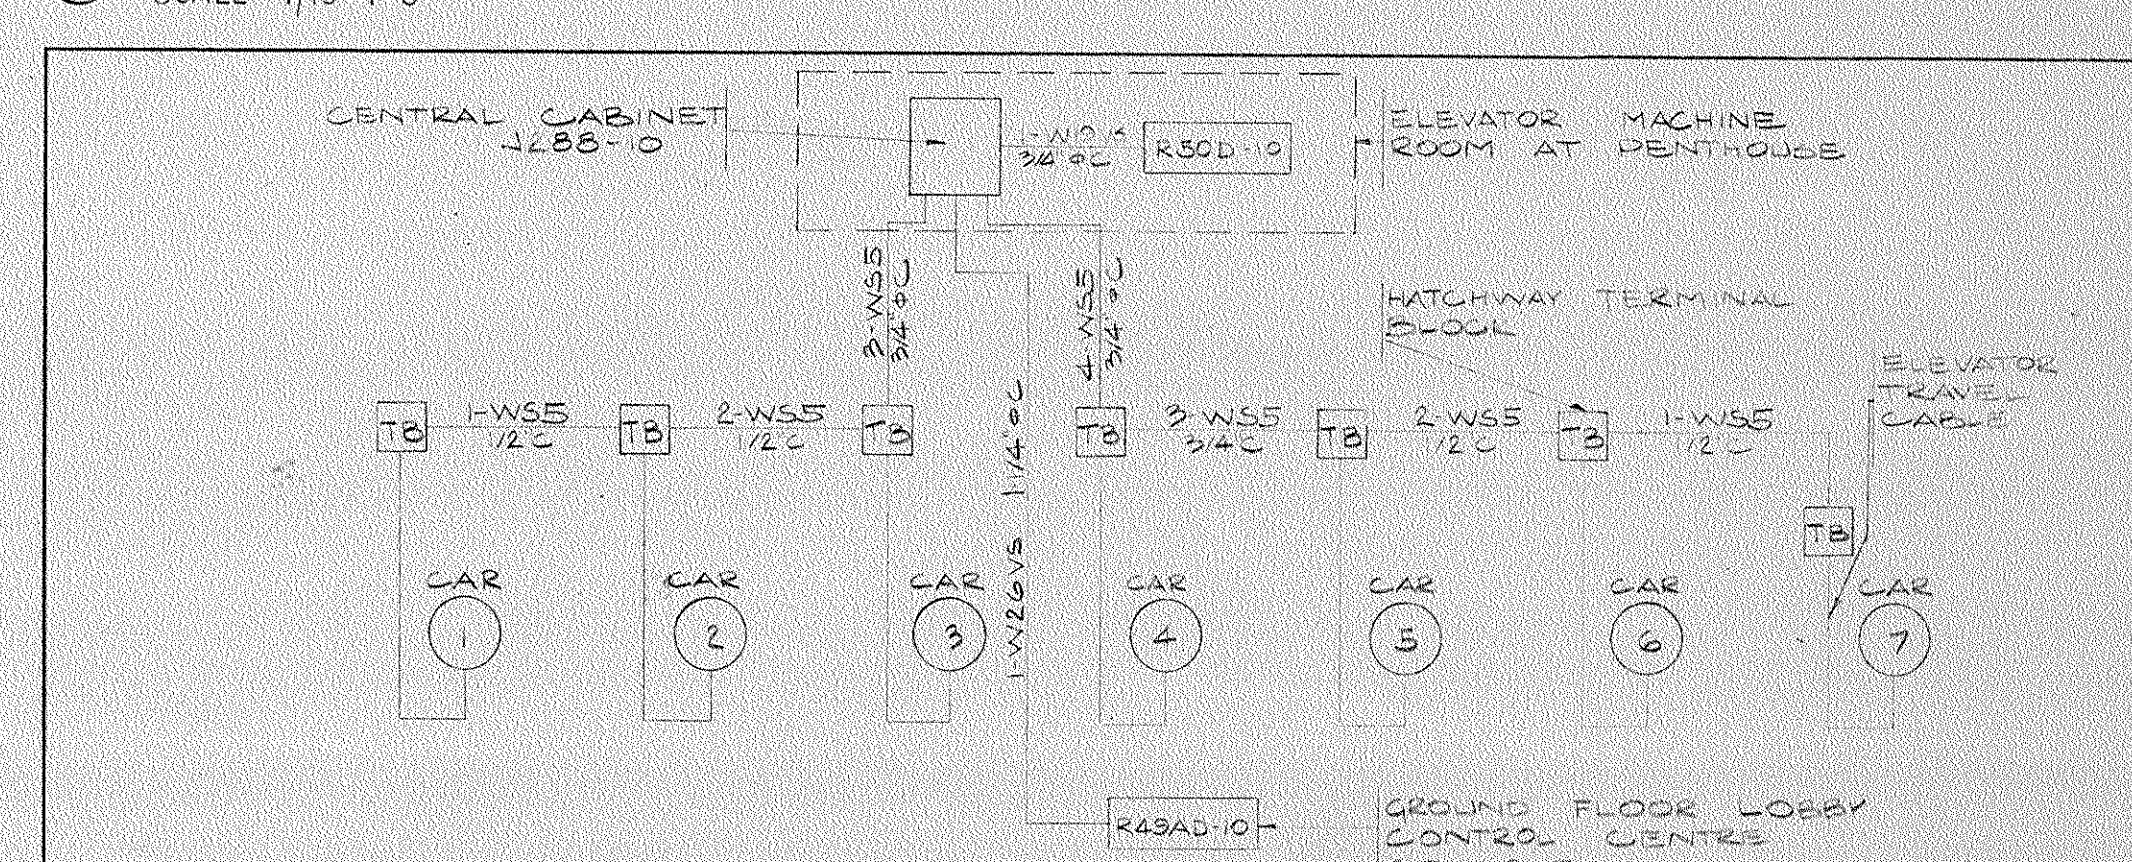


8 RISER LAYOUT - EMERGENCY ELEVATOR
INTERCOM SYSTEM N.T.S.

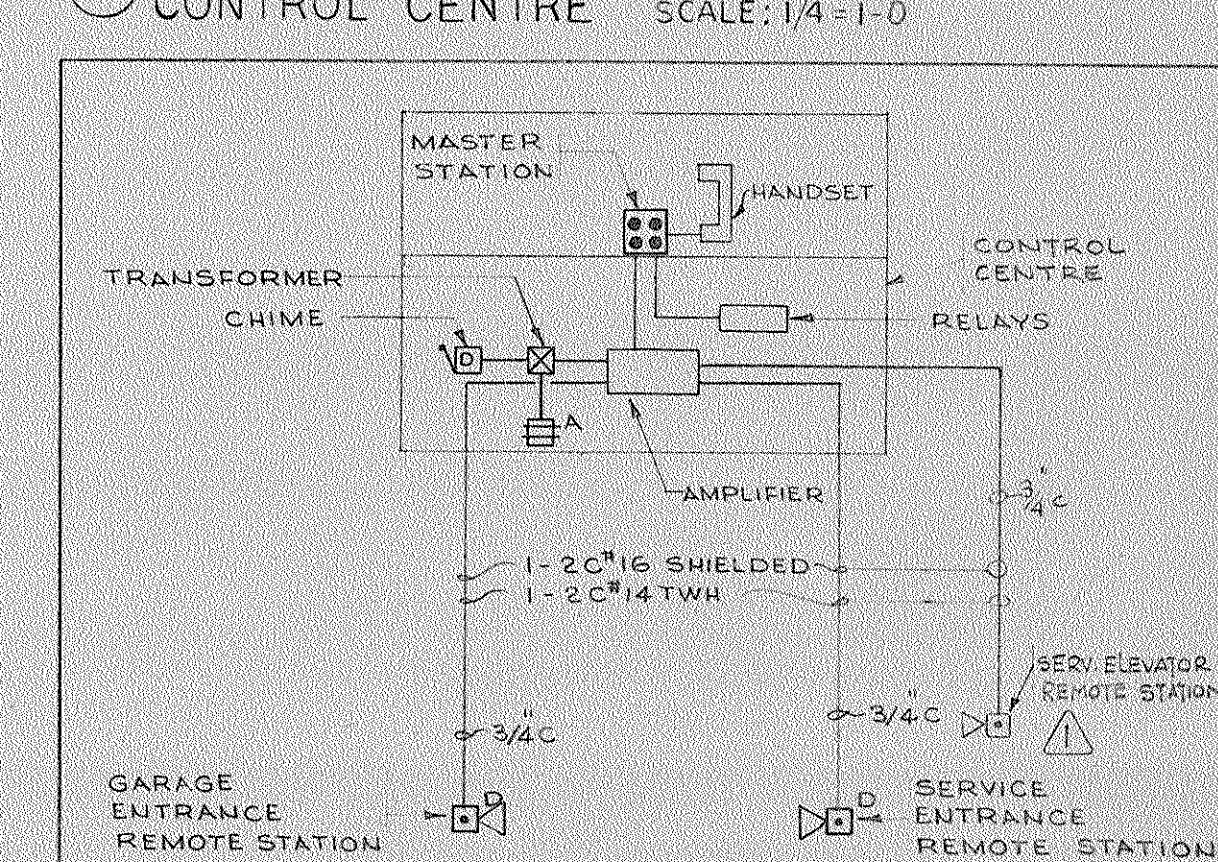


9 INTERCOM SYSTEM.
N.T.S.

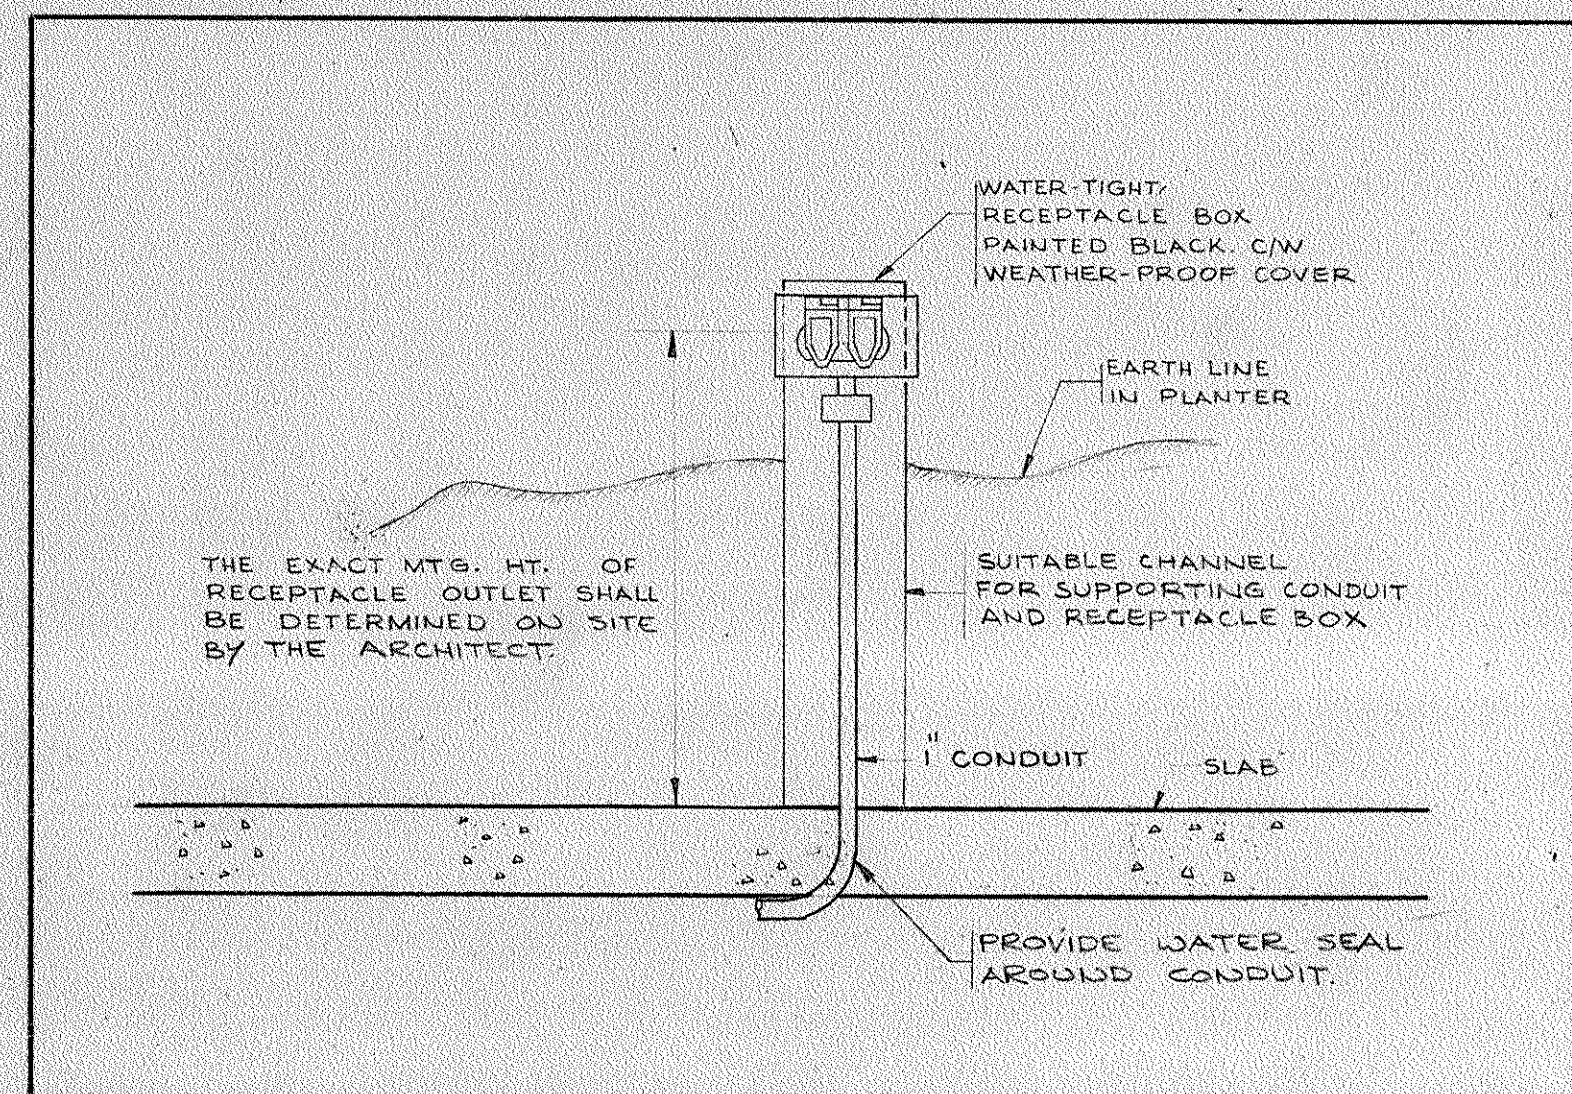


⑩ MOUNTING OF RECEPTACLE IN PLANTER
N.T.S.

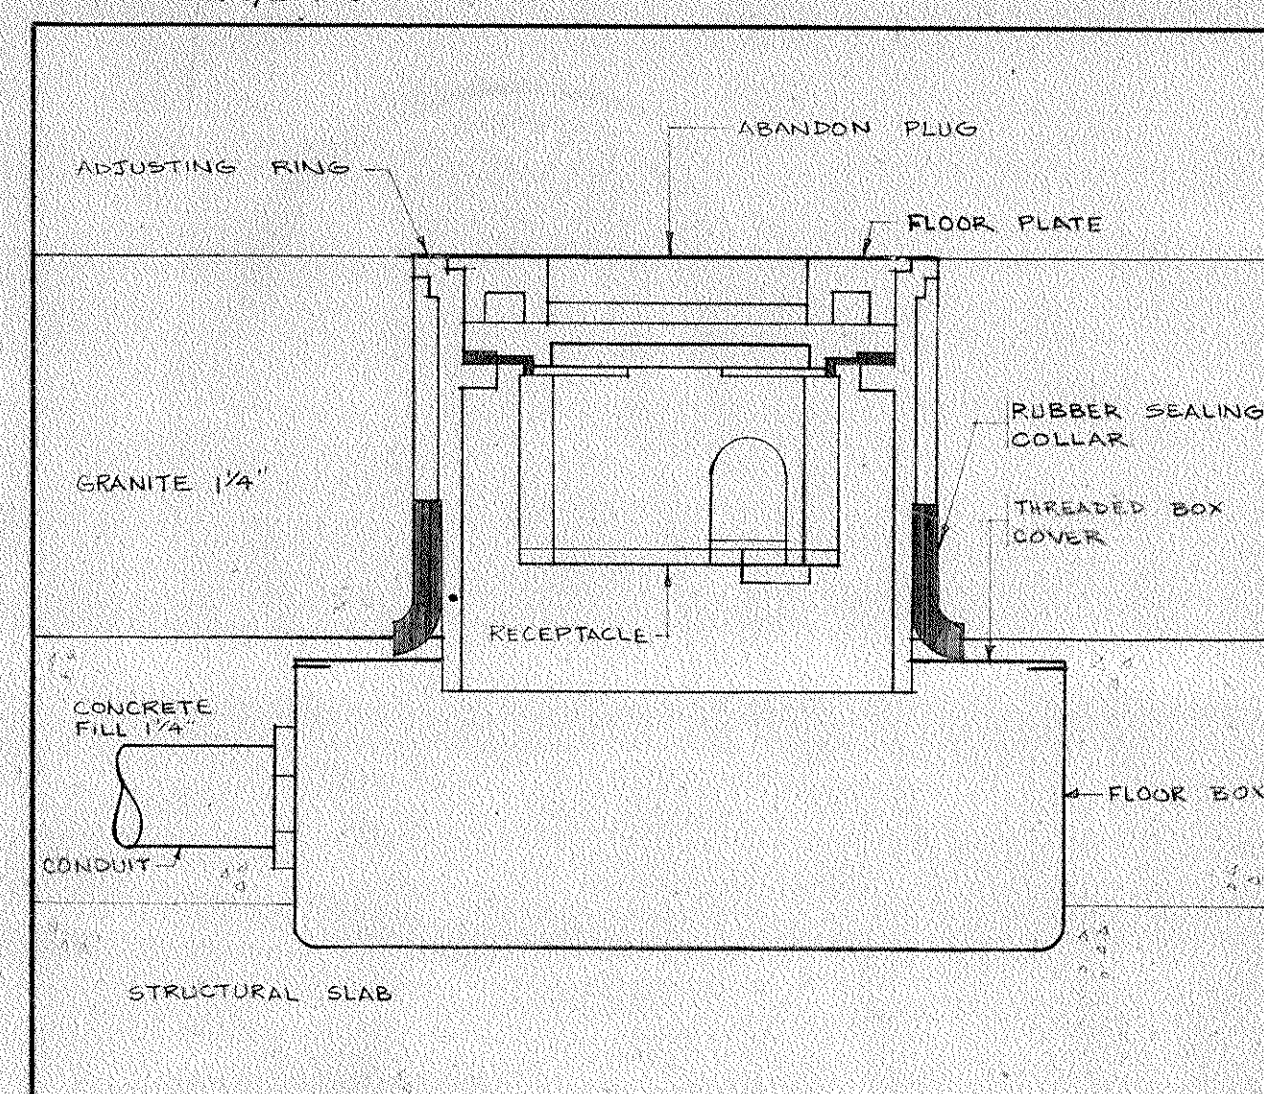


II DETAIL - FLUSH FLOOR OUTLET (GROUND FLOOR LOBBY) N.T.S.

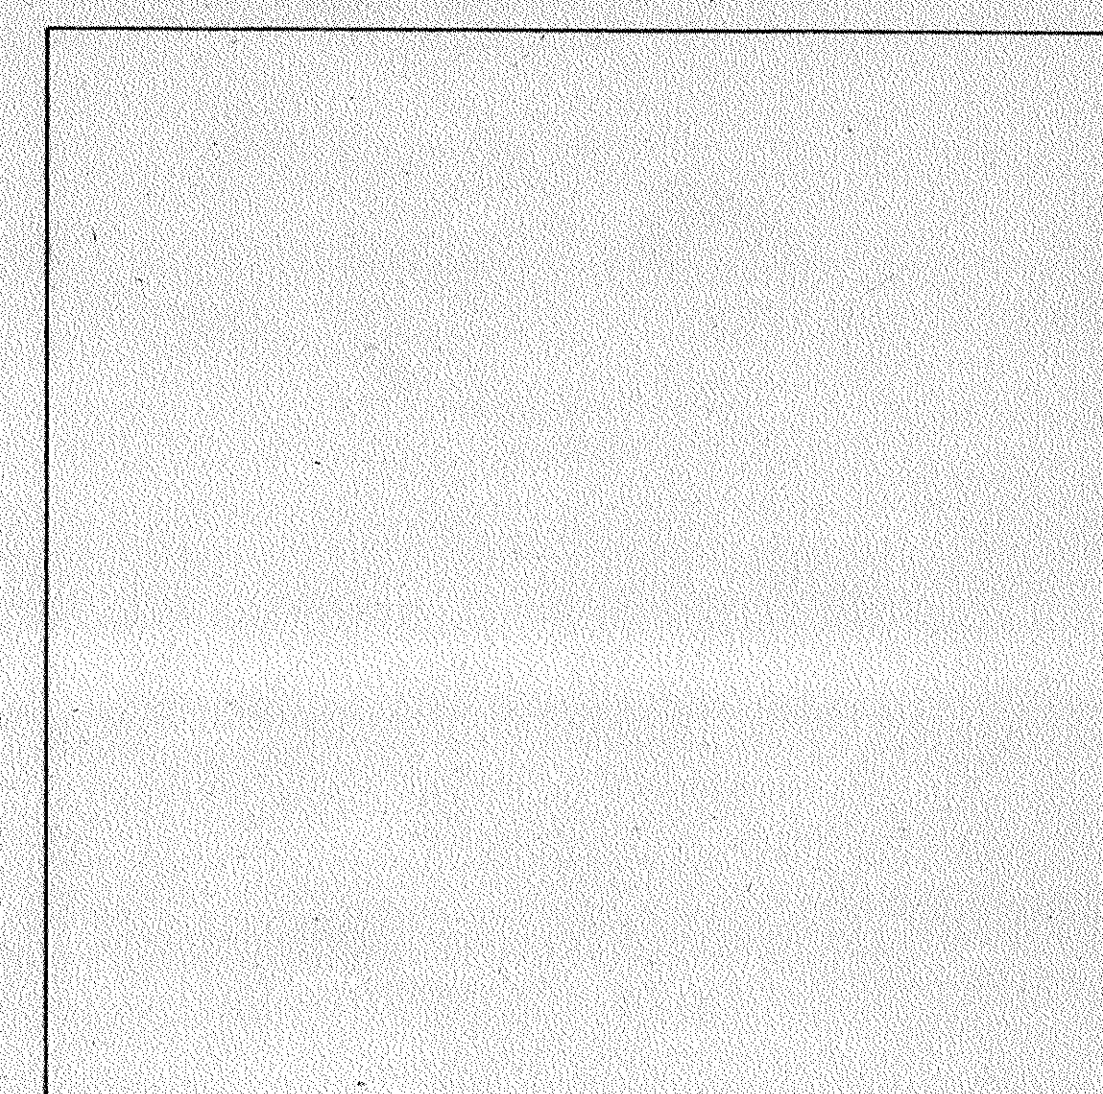



12

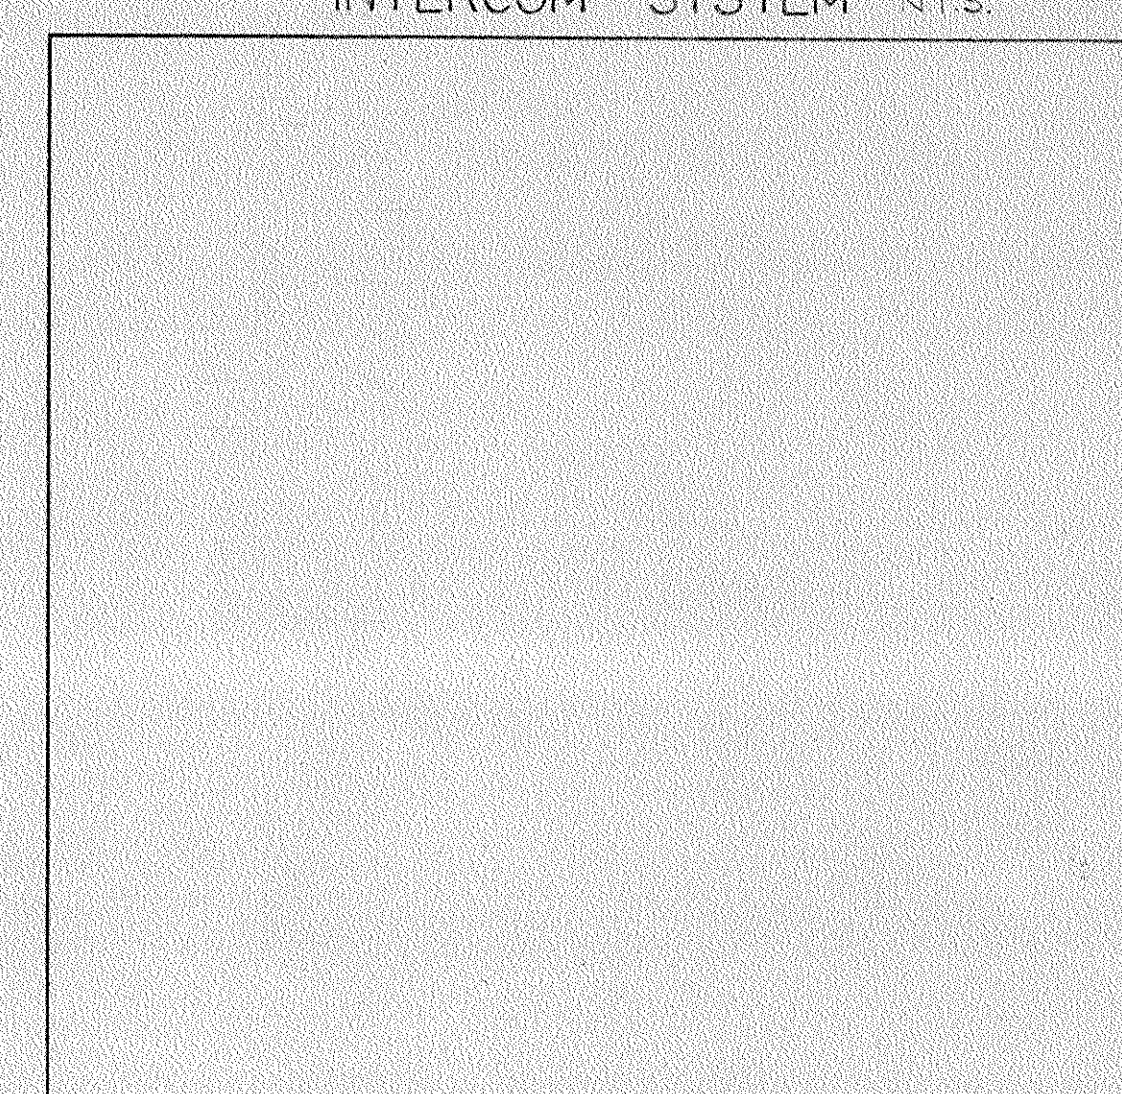


13

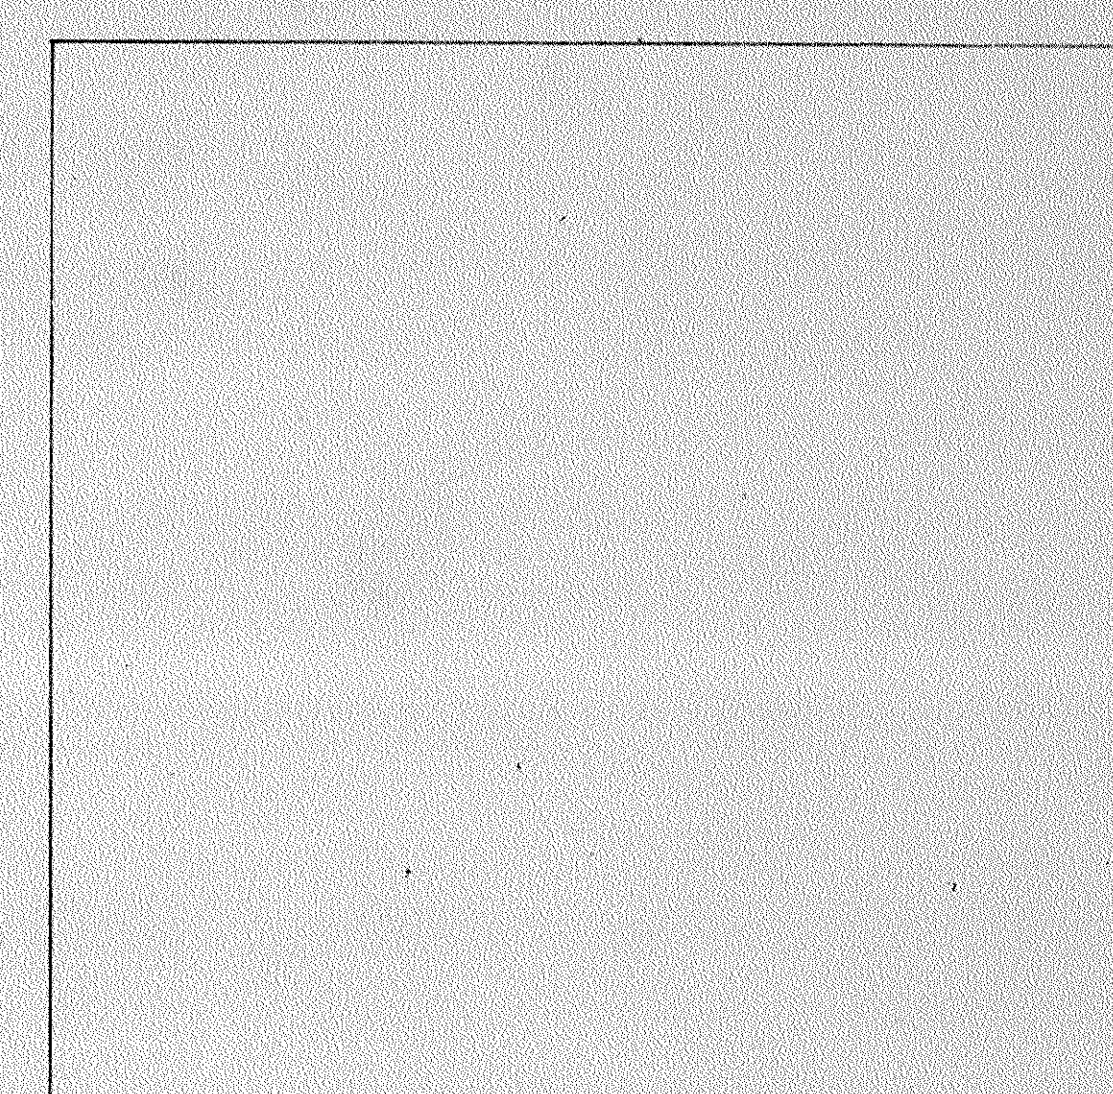


14

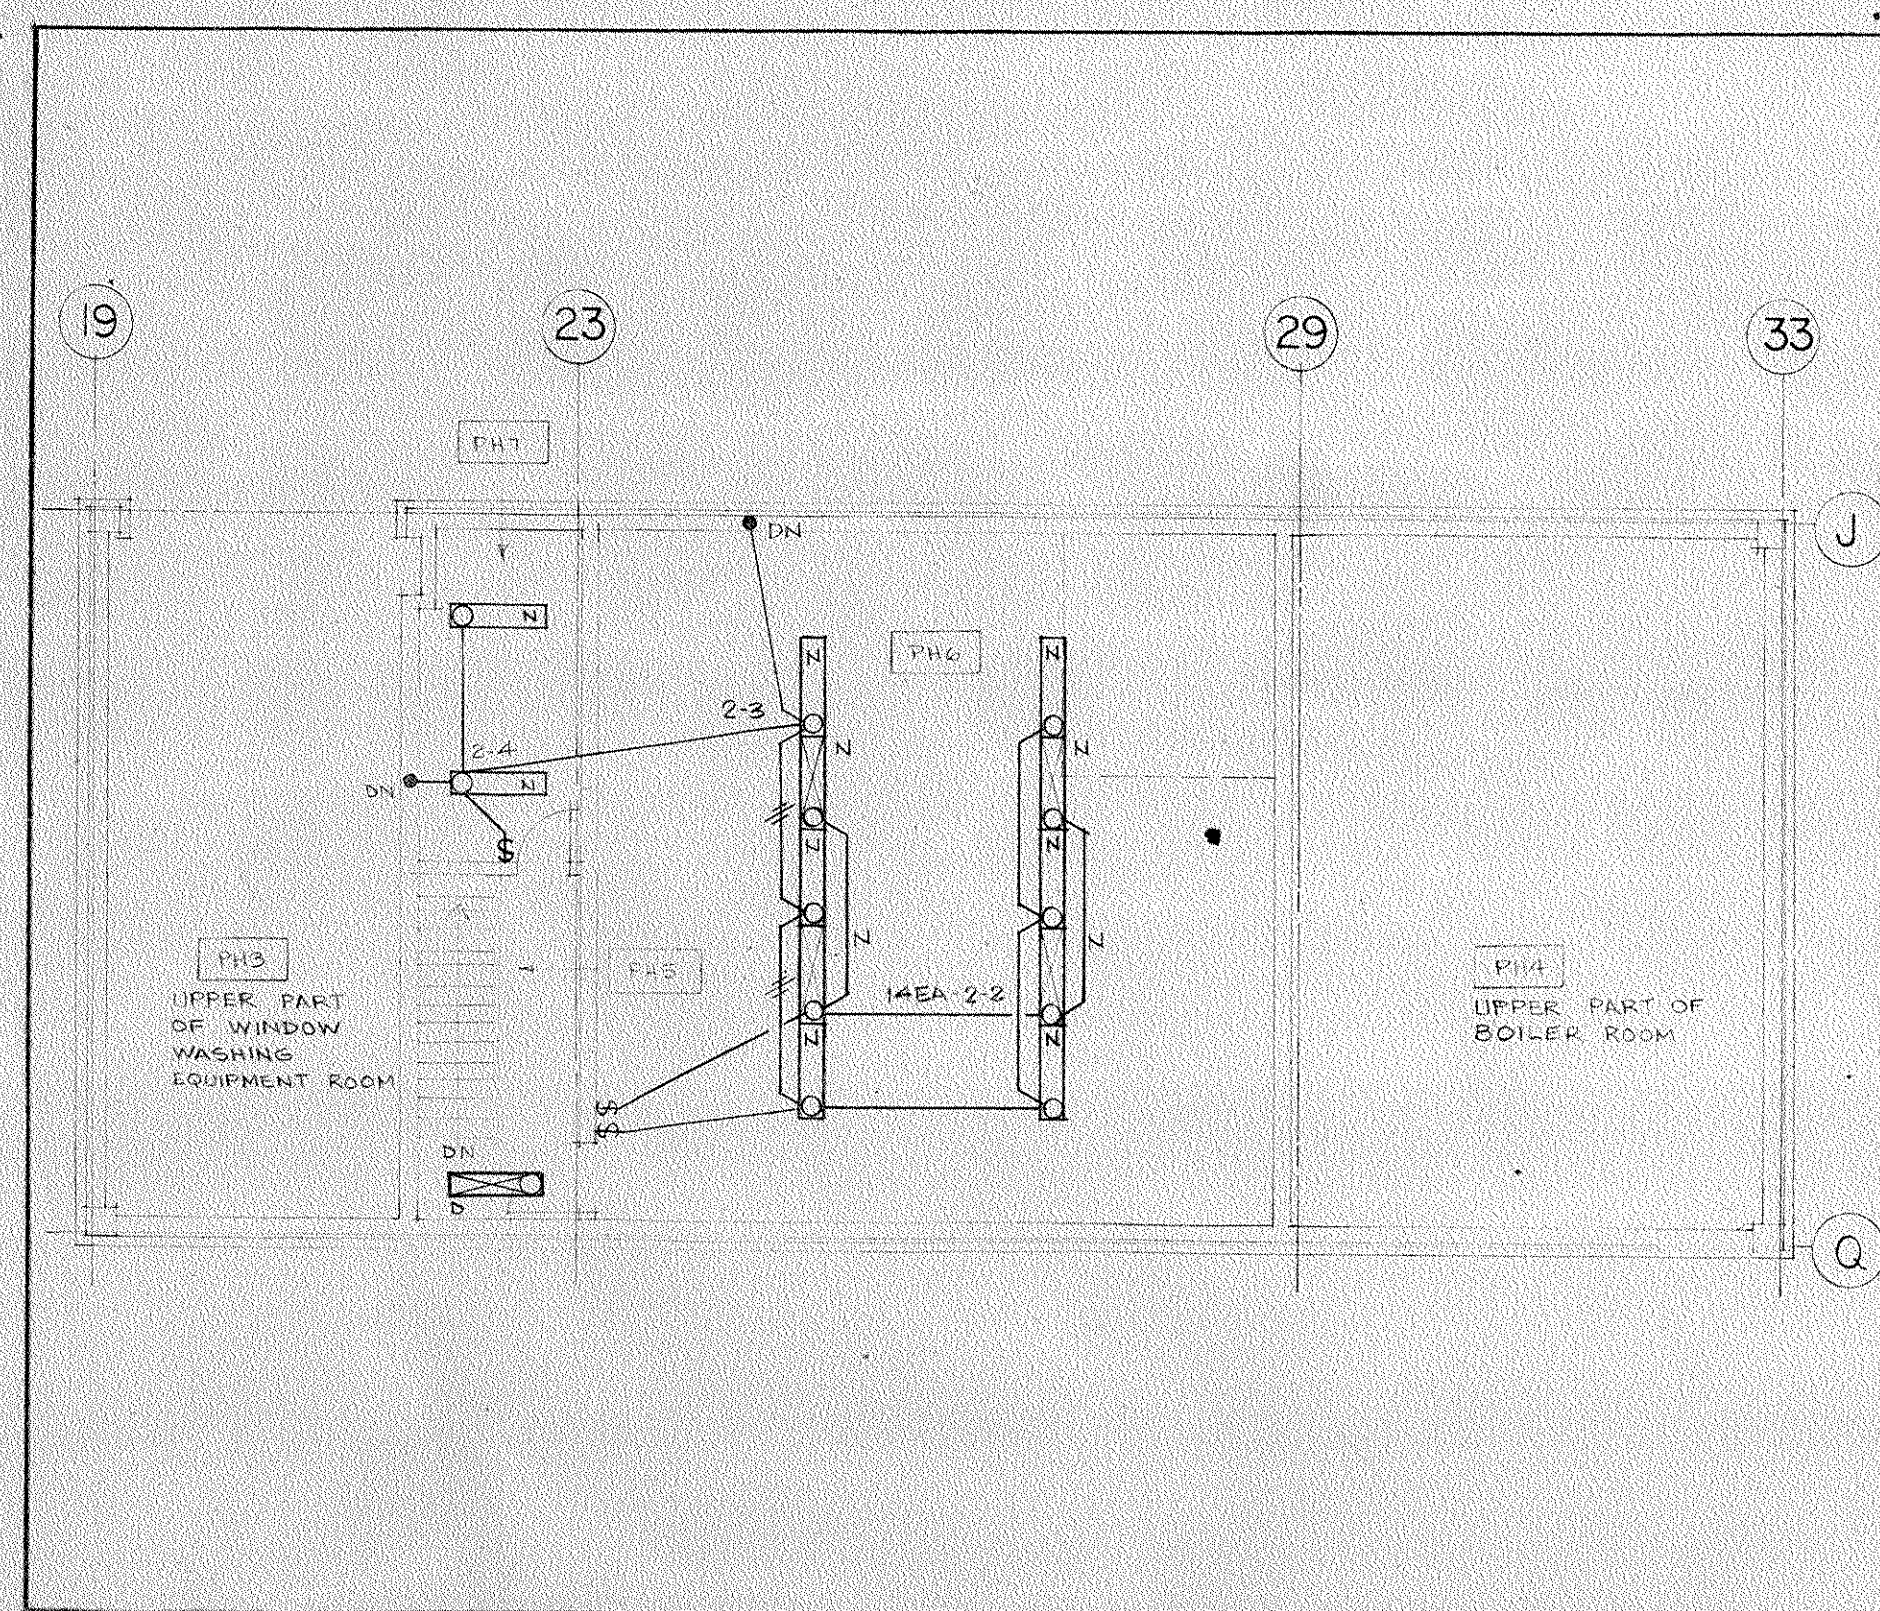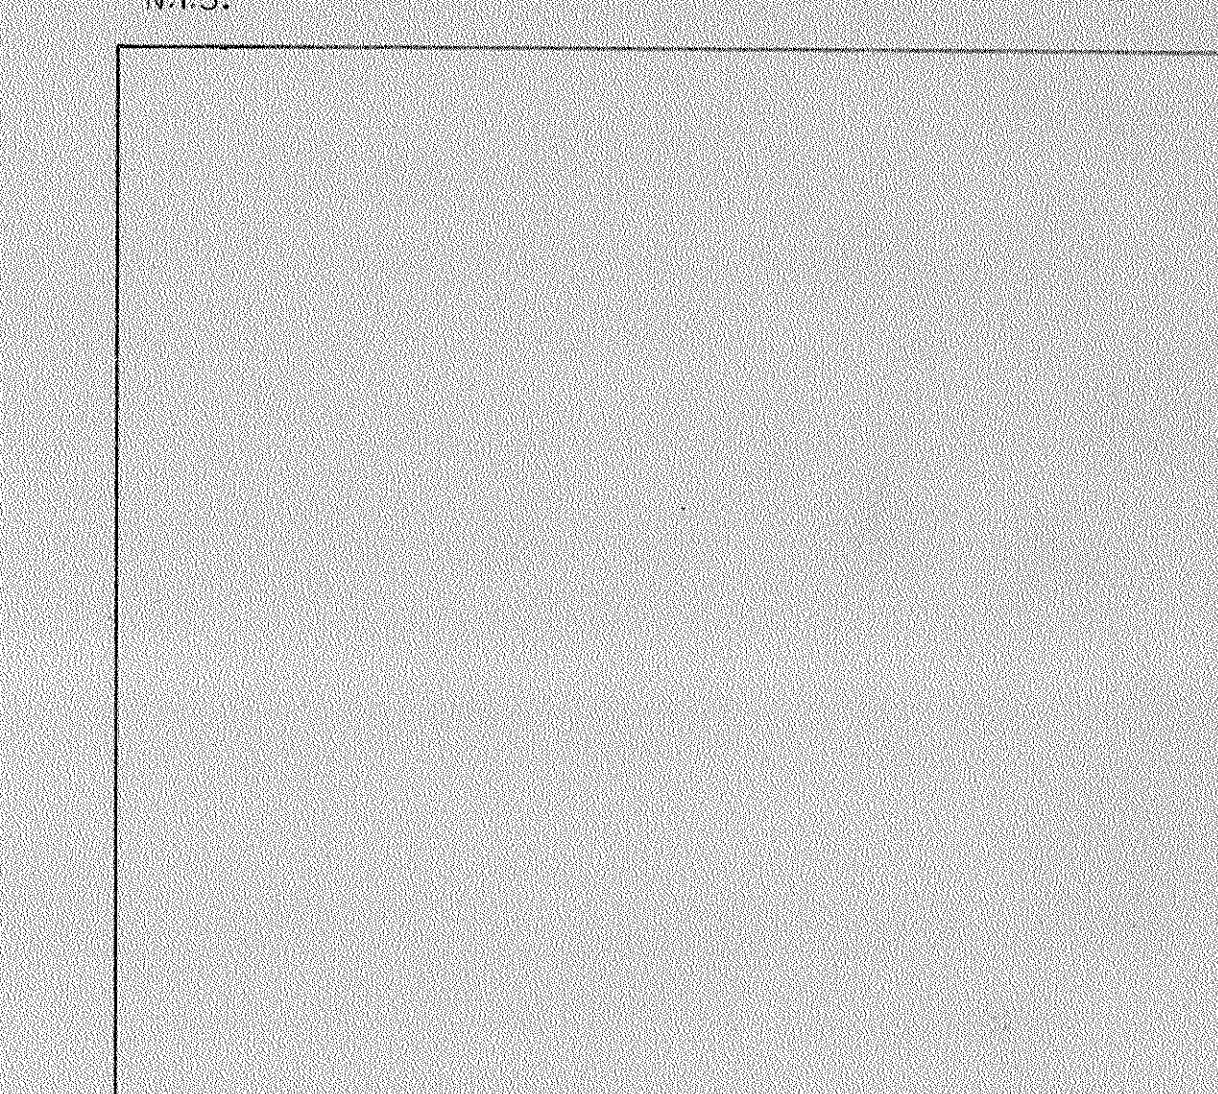


16 PENTHOUSE PLAN - MACHINE ROOM LEVEL TWO - LIGHTING
SCALE 1/8"=1'-0"

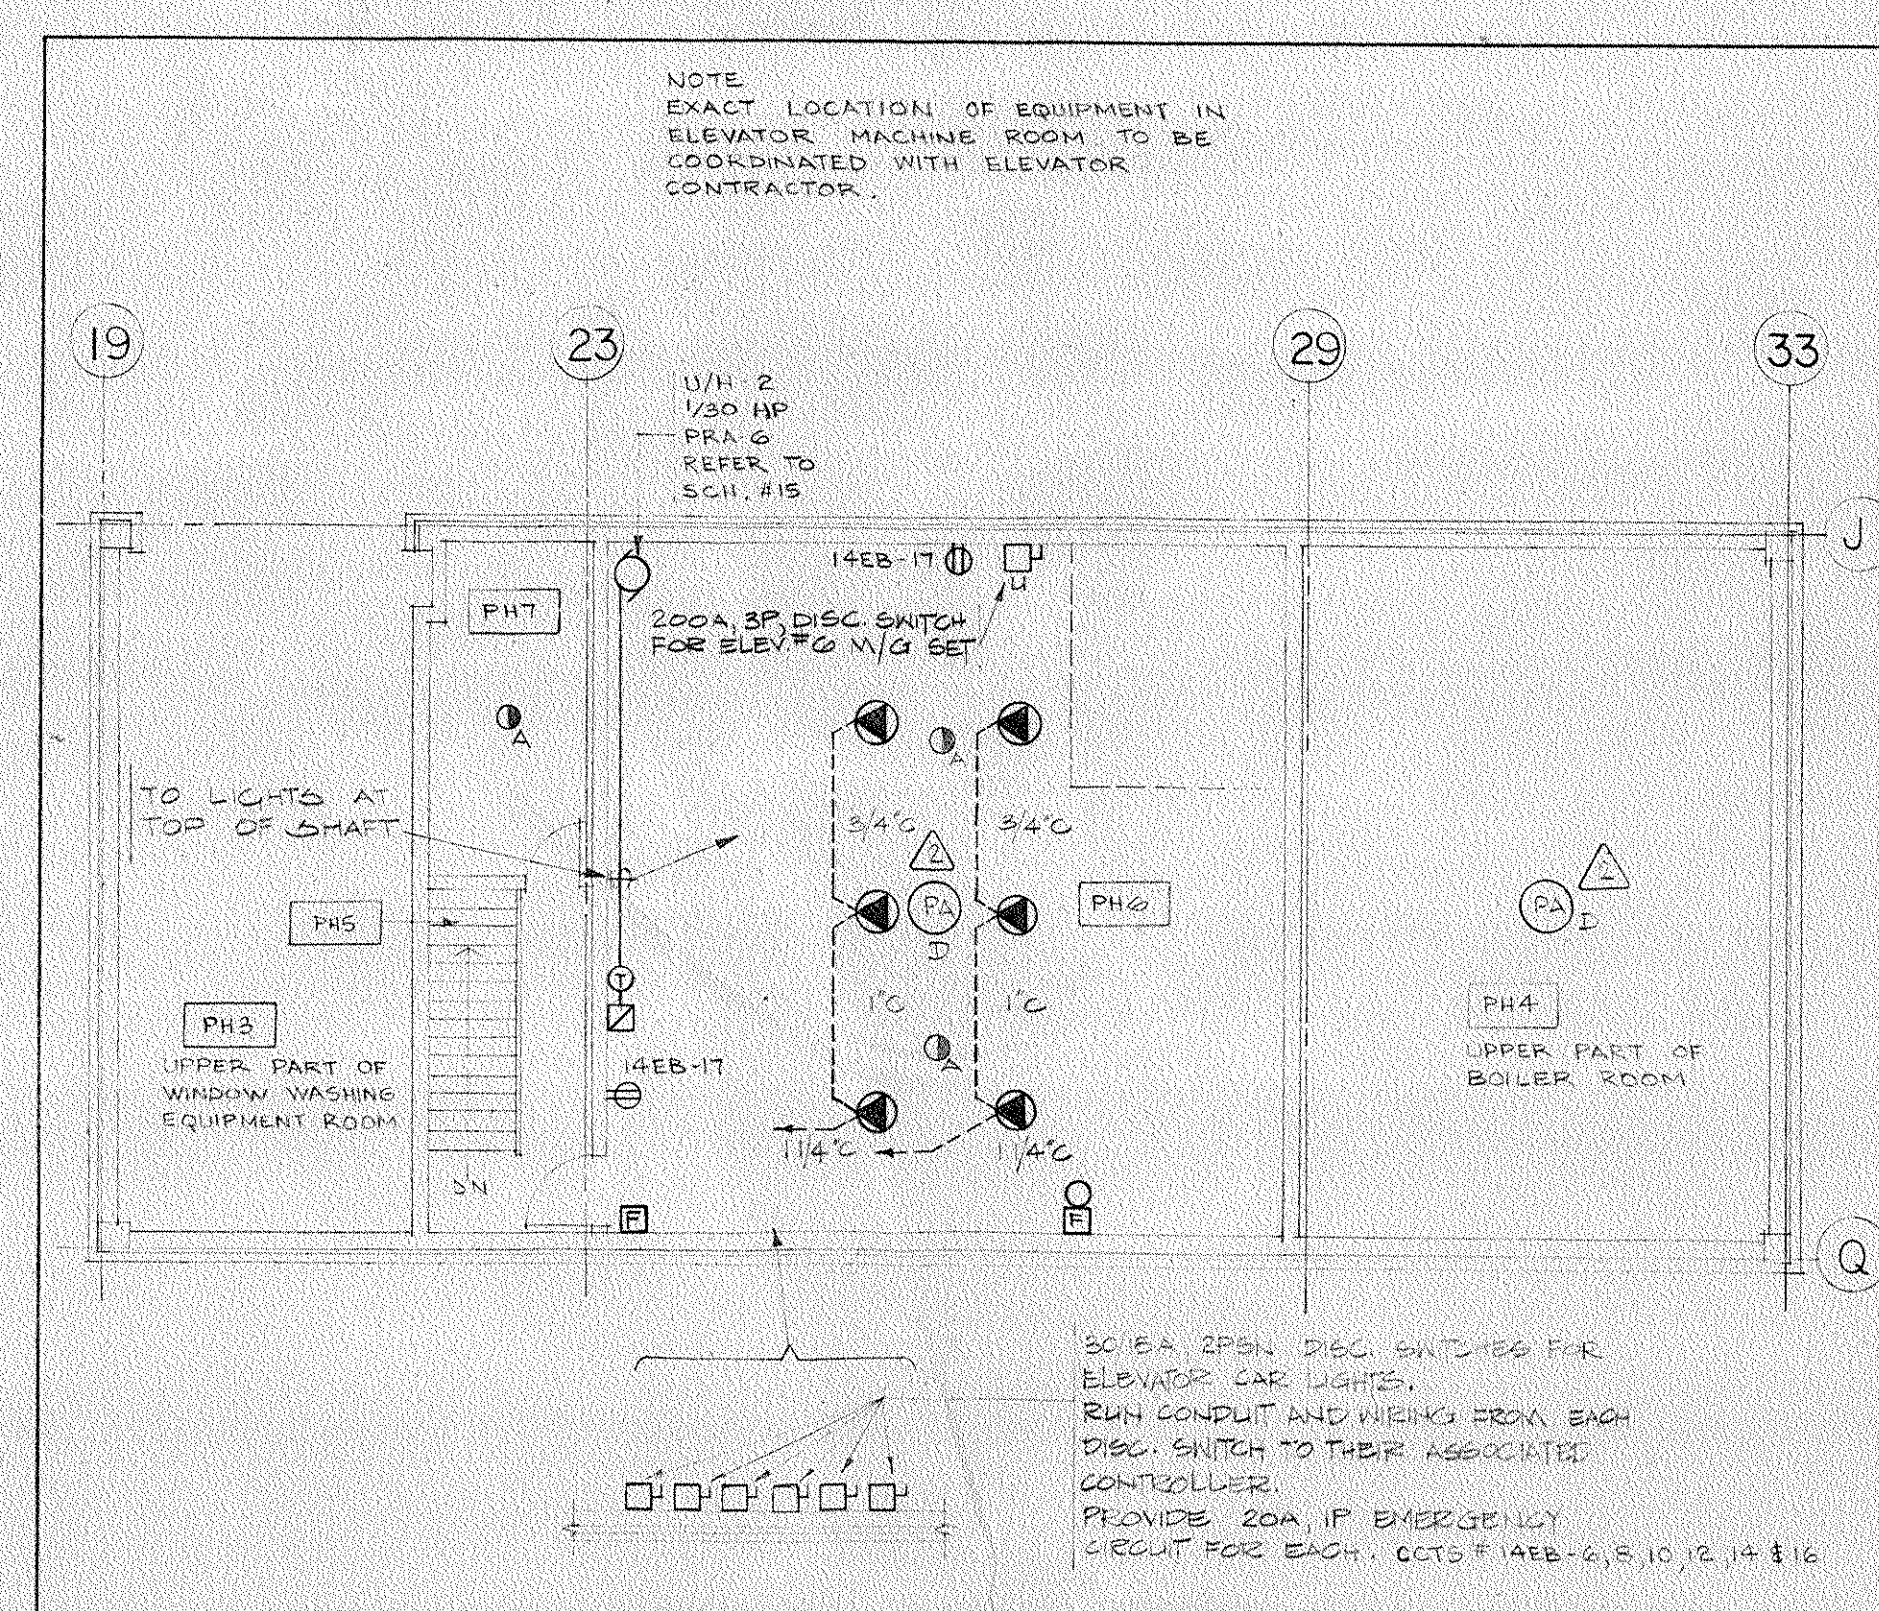

17 PENTHOUSE PLAN - MACHINE ROOM LEVEL TWO - POWER
SCALE 1/8"=1'-0"

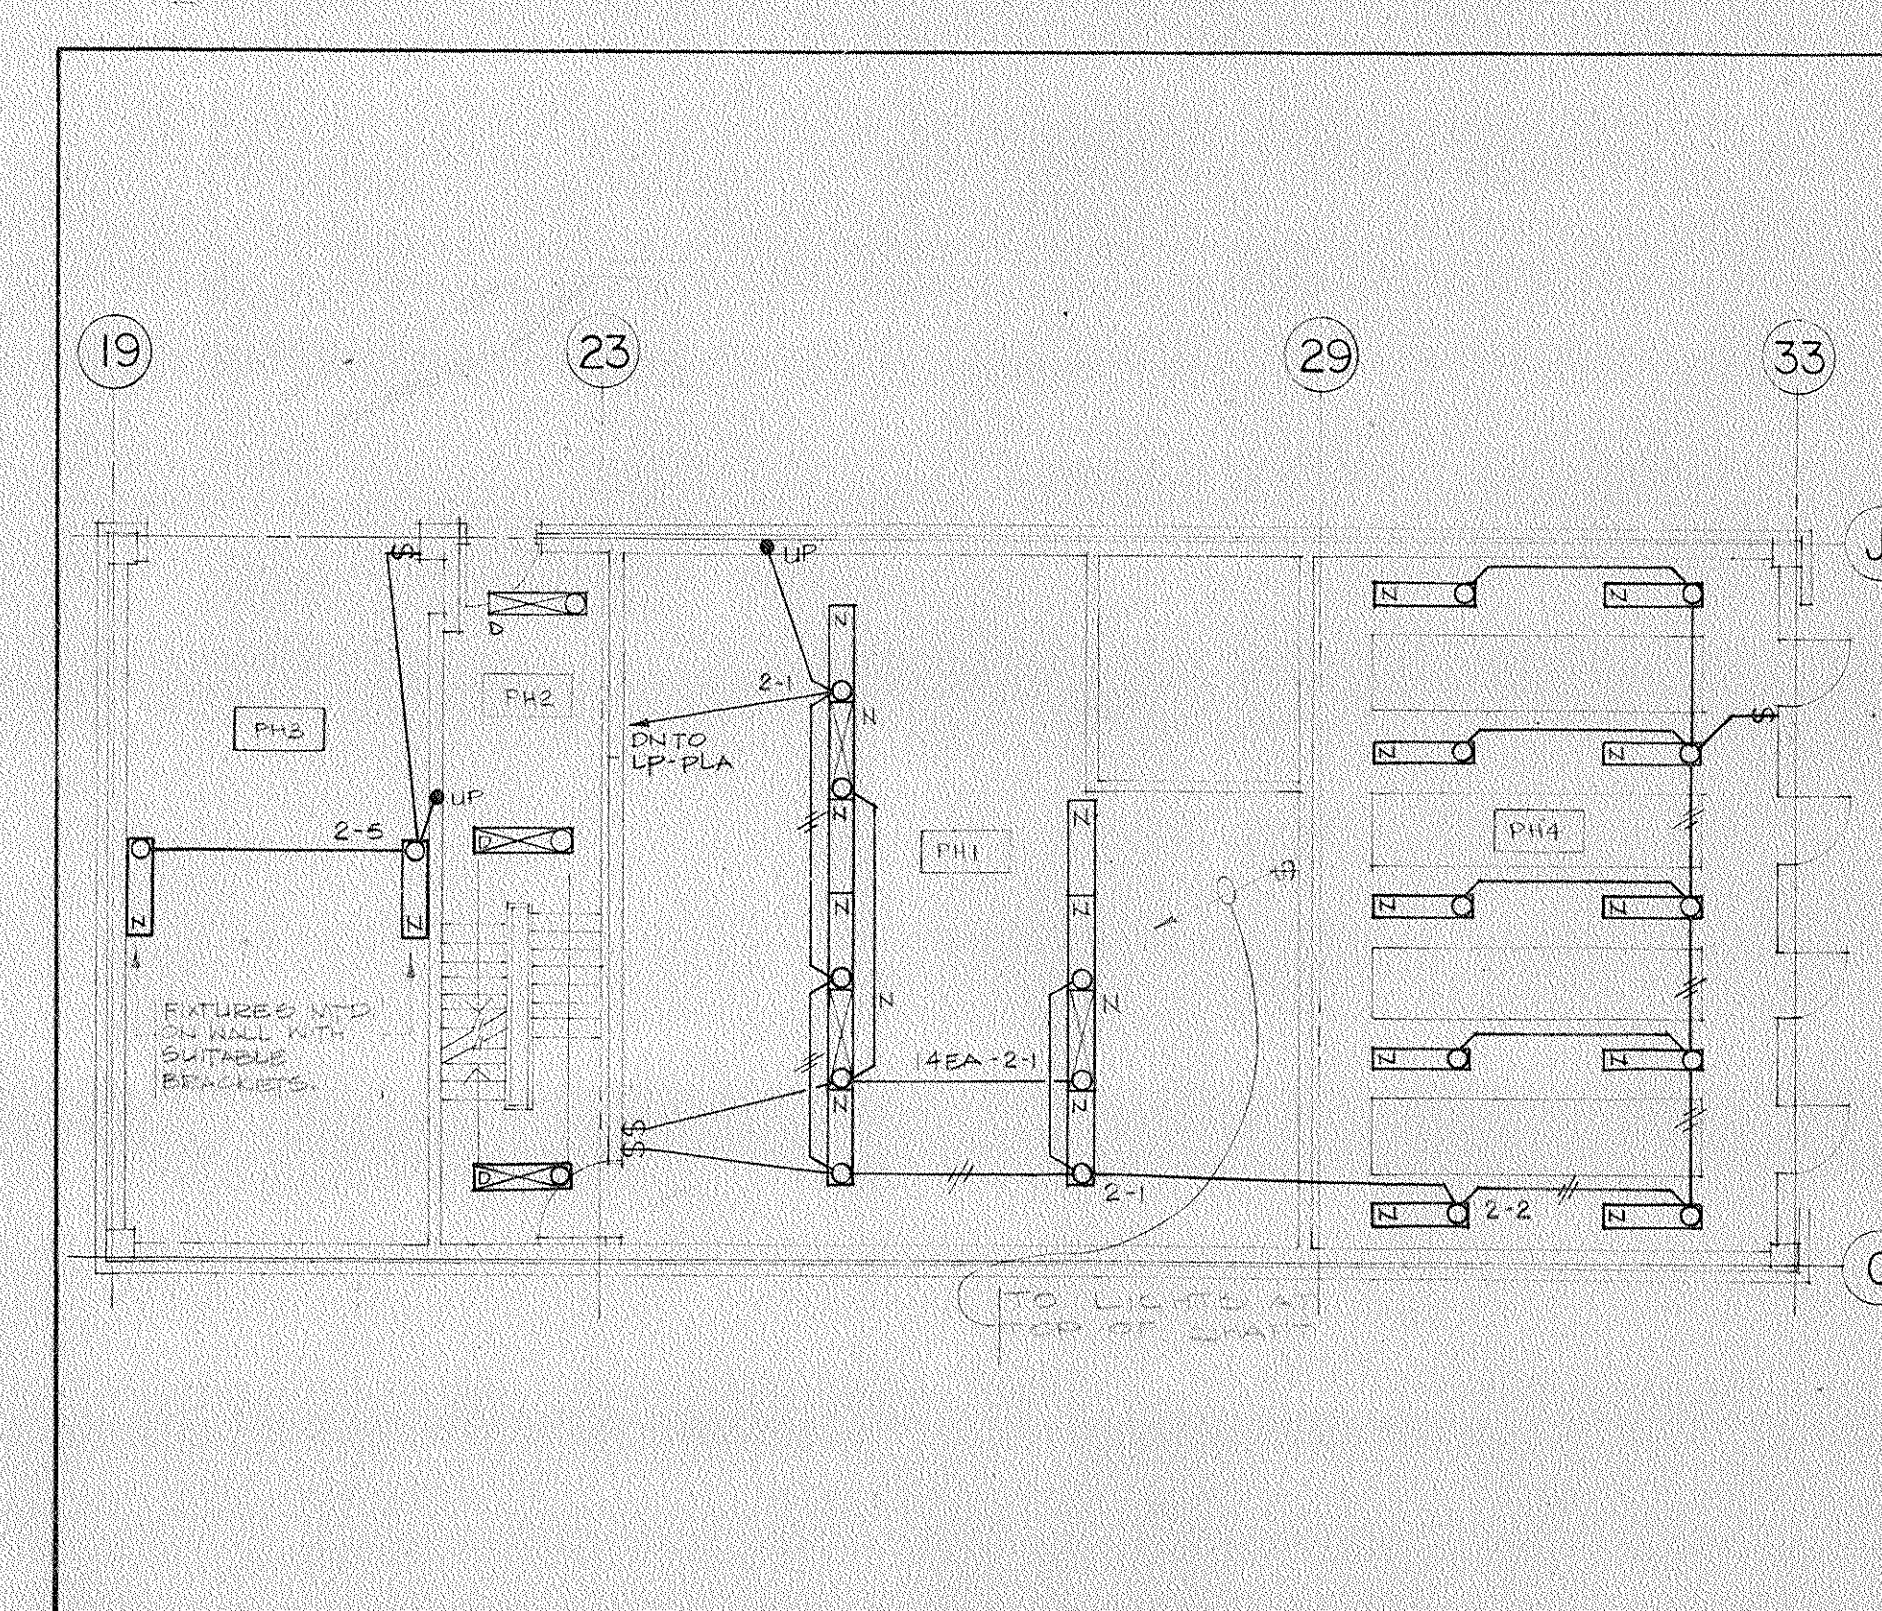

18 PENTHOUSE PLAN-MACHINE ROOM LEVEL ONE-LIGHTING
SCALE 1/8"=1'-0"

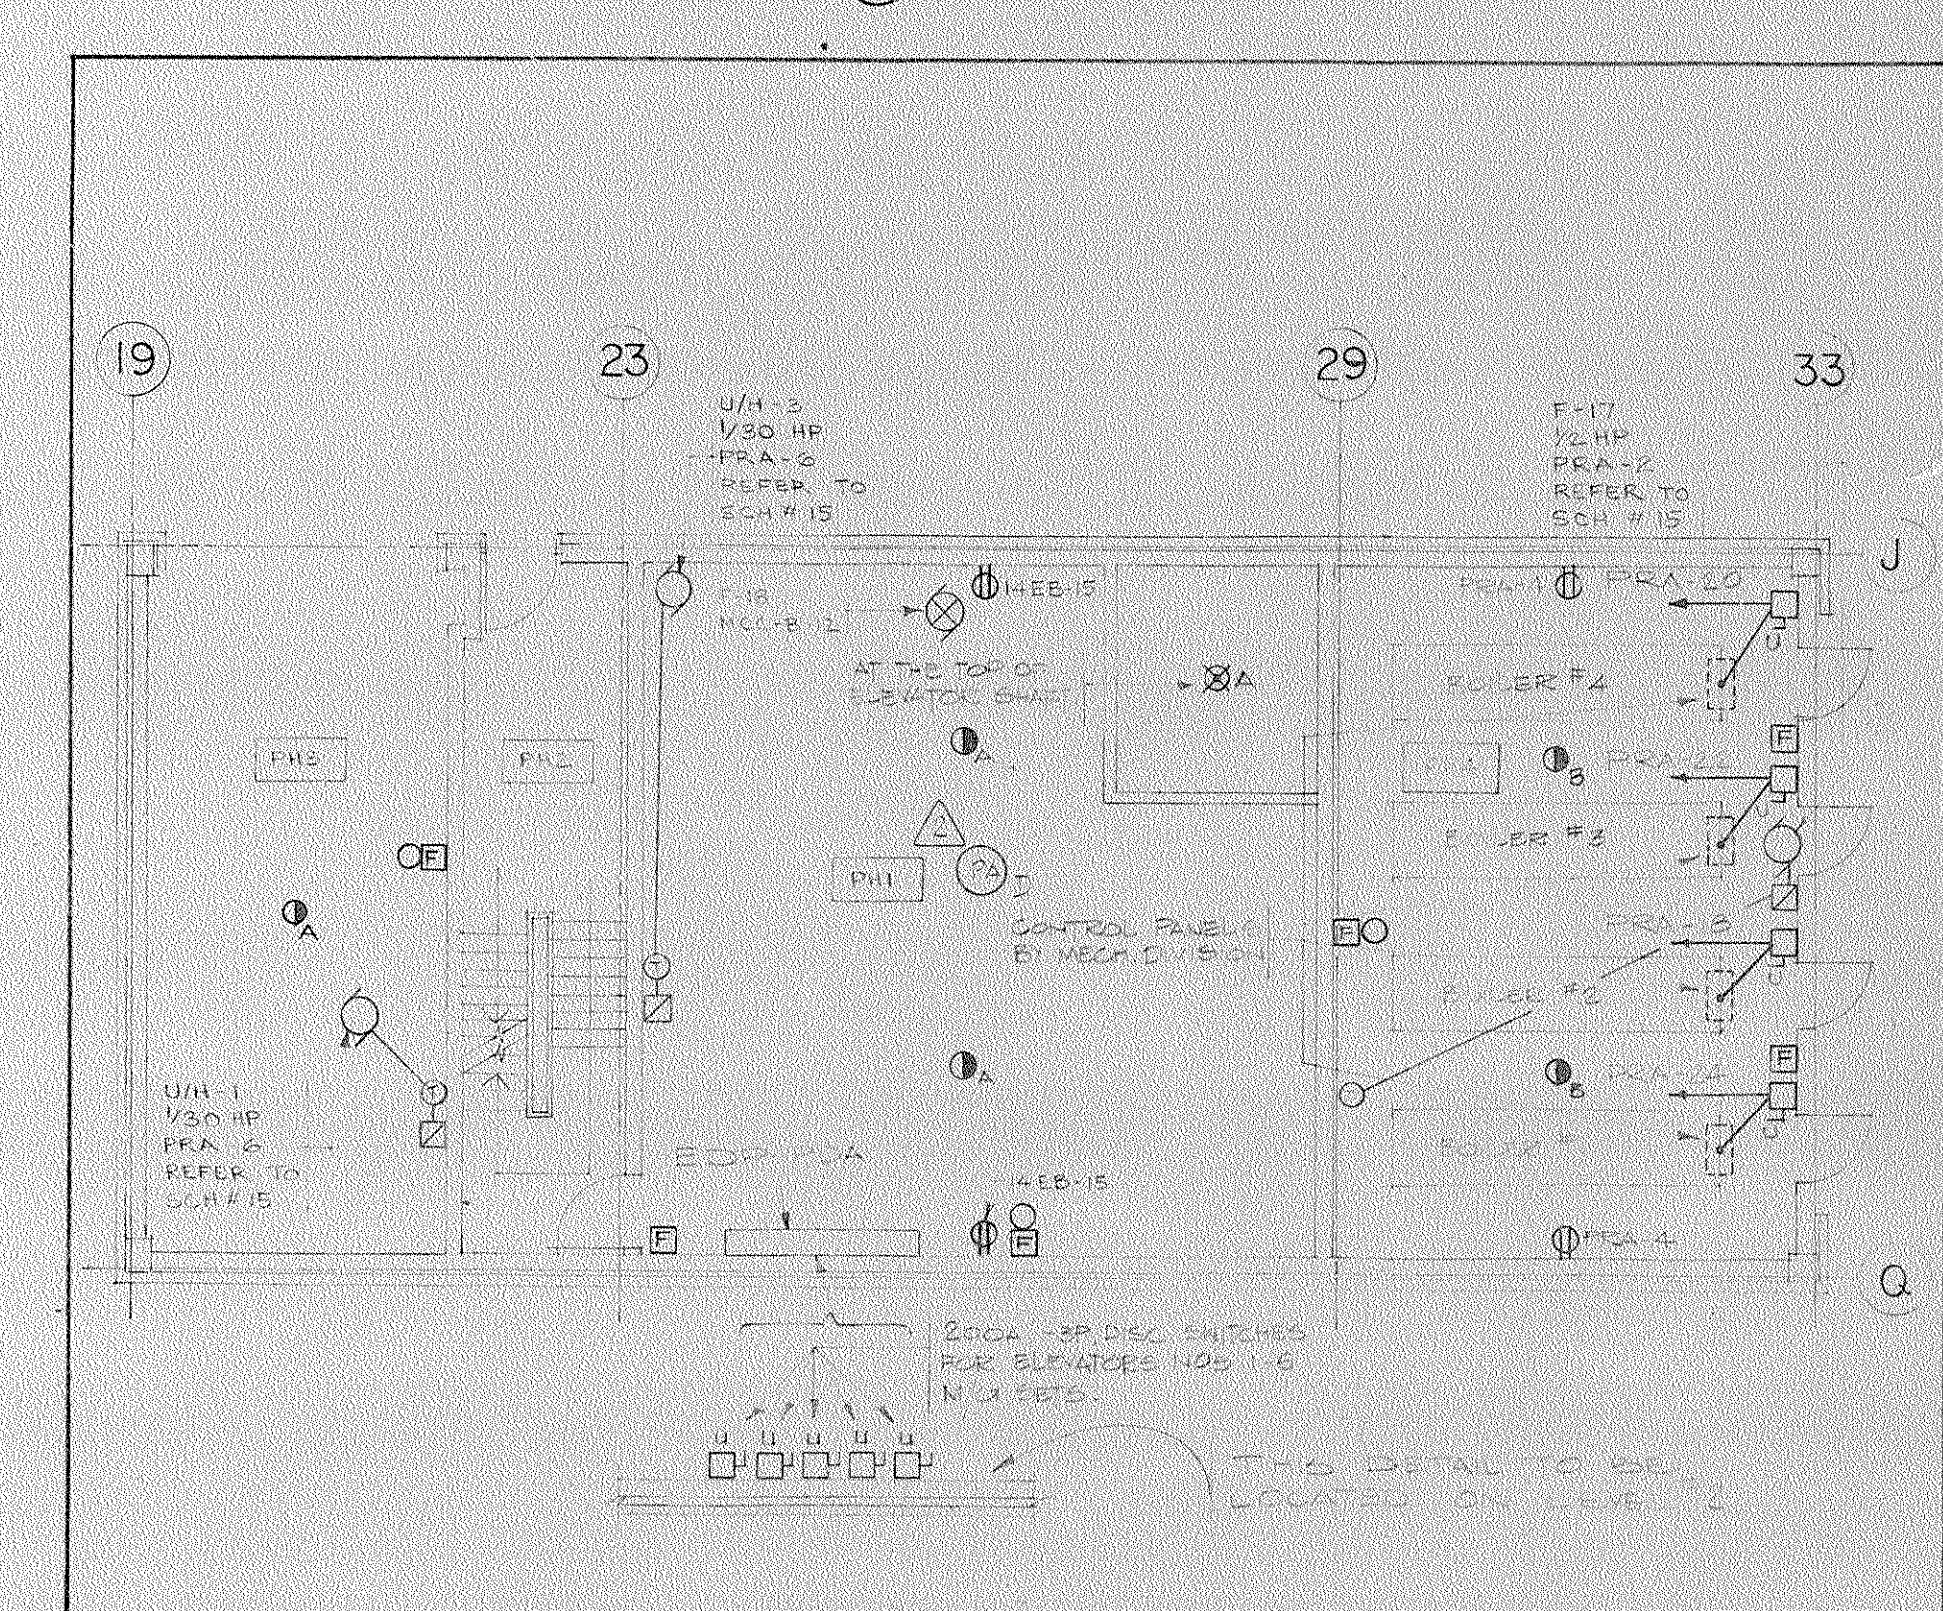

(19) PENTHOUSE PLAN - MACHINE ROOM LEVEL ONE - POWER
SCALE 1/8"=1'-0"


THE LOCATION OF EQUIPMENT SUCH AS AIR DIFFUSERS, IS SHOWN IN DRAWING 10. THE EXACT LOCATION OF EACH SUCH EQUIPMENT SHALL BE CO-ORDINATED BY THE CONTRACTOR TO THE LOCATION OF THE EXISTING CEILING GRID PATTERN. THE CONTRACTOR SHALL ENSURE THAT THE LOCATIONS ARE APPROVED BY THE ARCHITECT BEFORE THE EQUIPMENT IS INSTALLED.

THE LOCATION OF EQUIPMENT SUCH AS SWITCHES, THERMOSTATS AND CONTROLS SHALL BE CO-ORDINATED BY THE CONTRACTOR SHALL CO-ORDINATE THE EXACT LOCATION KEEPING ALL EQUIPMENT CLEAR OF THE WALLS, DOOR JAMBS AND OTHER OPENINGS AS POSSIBLE. WHEN MOUNTED ON ROLLED STEEL CHANNELS, THE EQUIPMENT SHALL BE MOUNTED ON THE WEST SIDE OF THE COLUMN UNLESS NOTED OTHERWISE.

THE CONTRACTOR SHALL ENSURE THAT THE LOCATIONS ARE APPROVED BY THE ARCHITECT BEFORE THE EQUIPMENT IS INSTALLED.

ALL METAL PARTS OF EQUIPMENT EXPOSED ON THE EXTERIOR OF THE BUILDING SHALL BE CO-ORDINATED BY THE ARCHITECT TO A UNIFORM COLOUR THROUGHOUT.

8	AS BUILT	3441	1
7	REN FOR NO. 7	3441	1
6	REN FOR NO. 25	3441	1
5	REN FOR NO. 29	3441	1
4	REN FOR NO. 21	3441	1
3	REN FOR NO. 21	3441	1
2	REN FOR NO. 21	3441	1
1	REN FOR NO. 21	3441	1
No. Ref.	Description	Date	Chd

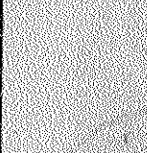Revisions	
Drawn GM/S CD	 NORTH
Date FEB 1971	
Checked C.A.	
Pre-Design	
Design PW	
Architectural LAC	
Structural EJ	
Heating AL	
Sanitary AC	
Electrical CA	
Specifications CK	
Process	
Printed	

All measurements must be checked on the work by the contractor.

All prints and specifications are the property of the architects and must be returned at the completion of the work.

This drawing not to be used for construction until countersigned by:

NATIONAL LIFE
OF CANADA

Head Office Building
University Avenue, Toronto, Canada

**Searle
Wilbee
Rowland**

This drawing is the property of
Meish Owen Rowland & Roy

ELECTRICAL
ROOF PLANS

Sheet
Title **AND DETAILS**
Scale **AS SHOWN**

AS SHOWN
Sheet
Number 69039-51